



August 12, 2022

VIA ELECTRONIC AND FEDERAL EXPRESS

Melanie A. Bachman, Executive Director
Connecticut Siting Council
10 Franklin Square
New Britain, CT 06051

New Cingular Wireless PCS, LLC (“AT&T”)
Notice of Exempt Modification
Emergency Back-up Generator
103 (202) Great Hollow Road, Woodbury, CT 06019
Lat.: 41.52199810; Long.: -073.22073500

Dear Ms. Bachman:

This letter and enclosures are respectfully submitted on behalf of New Cingular Wireless PCS, LLC (“AT&T”). AT&T currently maintains its wireless telecommunications facility on the existing tower located at 103 (202) Great Hollow Road in the Town of Woodbury, Connecticut. The underlying property is owned by O & G Industries Inc. and the tower structure is owned by Crown Castle. AT&T submits this letter and enclosures to the Connecticut Siting Council (“Council”) to notify the Council of AT&T’s intent to perform modifications to the existing facility that do not have substantial adverse environmental effects and thus do not require a certificate pursuant to Section 16-50k of the Connecticut General Statutes.

AT&T intends to install one (1) new Generac 30kW Diesel Generator within the existing grade-level fenced equipment compound as demonstrated on the plans enclosed as Attachment 1. AT&T’s existing facility supports its FirstNet program which provides first responders with priority access to AT&T’s network to ensure adequate communication capabilities in the event of emergency. AT&T’s proposed generator will ensure that critical communication capability for first responders and the public are not lost in the event of a loss of power.

AT&T’s proposed generator will also advance the State’s goal of natural disaster and emergency preparedness. As discussed in the Council’s Docket 432 Findings and Report and Docket 440 proceedings and Findings of Fact (Nos. 76- 77), in response to two significant storm events in 2011, the State formed a Two Storm Panel (the “Panel”) that evaluated Connecticut’s approach to planning and mitigation of impacts associated with emergencies and natural disasters. The Panel found that “wireless telecommunications service providers were not prepared to serve residential and business customers during a power outage” because certain companies had limited backup generator capacity.

The Panel also noted that “[t]he failure of a large portion of Connecticut’s telecommunications system during the two storms is a life safety issue.” The Panel recommended that State regulatory bodies review “telecommunications services currently in place to verify that the vendors have sufficient generator and backhaul capacity to meet the emergency needs of consumers and businesses” and that the “Connecticut Siting Council should require continuity of service plans for any cellular tower to be erected.” The planned modifications will ensure continuity of services by reinforcing AT&T’s backup power and backhaul capacity to meet the emergency needs of first responders, consumers, and businesses in the event of a power outage.

The planned modifications to the facility fall squarely within the activities explicitly provided for in R.C.S.A. § 16-50j-72(b)(2) as the planned modifications:

- Will not result in an increase in the height of the existing structure;
- Will not require the extension of the site boundary;
- Will not increase noise levels at the facility by more than six decibels or more, or to levels that exceed state or local criteria since emergency backup generators are exempt from noise regulations as “noise created as a result of, or relating to, an emergency”;
- Will not increase radio frequency emission at the facility to a level at or above the Federal Communications Commission safety standards;
- Will not cause a change or alteration in the physical or environmental characteristics of the site; and
- Will not impair the structural integrity of the facility.

This modification complies with the aforementioned approval. AT&T’s proposed modification will maintain compliance with any relevant conditions these original approvals and any other subsequent approvals. The proposed modifications will have no impact on the existing tower structure itself or the radiofrequency emissions as the proposed modifications only consist of the addition of one new generator within the grade-level equipment compound. Thus, AT&T respectfully requests a waiver from submission of information relating to the existing tower structure or the radio-frequency emissions.



Please accept this letter as notification pursuant to R.C.S.A. § 16-50j-73 for construction that constitutes an exempt modification pursuant to R.C.S.A. § 16-50j-73. In accordance with R.C.S.A. § 16-50j-73, a copy of this letter and enclosure are being sent to the Town of Woodbury First Selectwoman Barbara Perkins and the Town of Woodbury Planning Department as well as the property owner and structure owner identified above. Certification of Service is enclosed as Attachment 3.

For the foregoing reasons, AT&T respectfully submits that the proposed modification to the above referenced wireless telecommunications facility constitutes an exempt modification under R.C.S.A. § 16-50j-72(b)(2).

Very truly yours,

Steven Volkert

Steven J. Volkert Site Acquisition Specialist

General Dynamics Wireless Services

2586 Industry Lane, Ste. 100

Norristown, Pa 19403

(318) 642-6190 phone

steven.volpert@gdit.com

GENERAL DYNAMICS
Information Technology

CC: Barbara Perkins, Town of Woodbury First Selectwoman

O & G Industries Inc., Property owner

Town of Woodbury Planning Department

ATTACHMENT 1



at&t Mobility

**SITE NAME:
OVERLAY - WOODBURY CT GREAT HOLLOW RD
FA LOCATION CODE: 10035444
CROWN BUN: 876380**









**GENERATOR PROJECT
30KW GENERAC DIESEL GENERATOR
200A GENERAC ATS**

**103 GREAT HOLLOW ROAD
WOODBURY, CT 06798**

**CONSULTANT:
GENERAL DYNAMICS**

Information Technology, Inc.
GENERAL DYNAMICS
101 STATION DR
WESTWOOD, MA 02090

Certification & Seal:
I hereby certify that this plan, specification, or report was prepared by me or under my direct supervision and that I am a duly licensed Professional Engineer under the laws of the State of Connecticut.

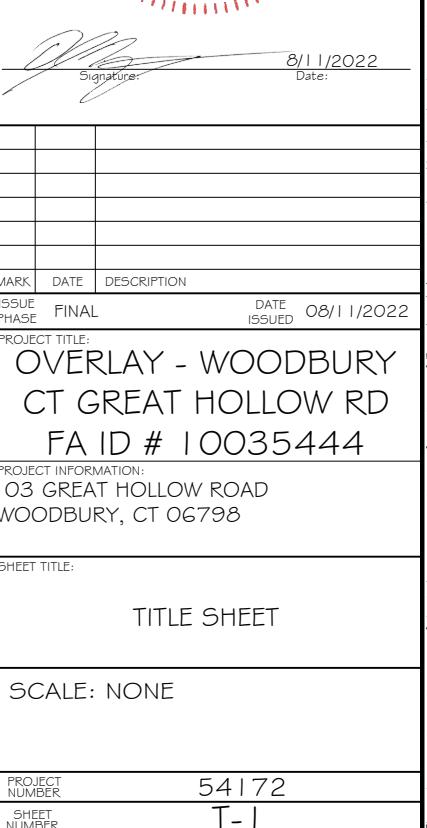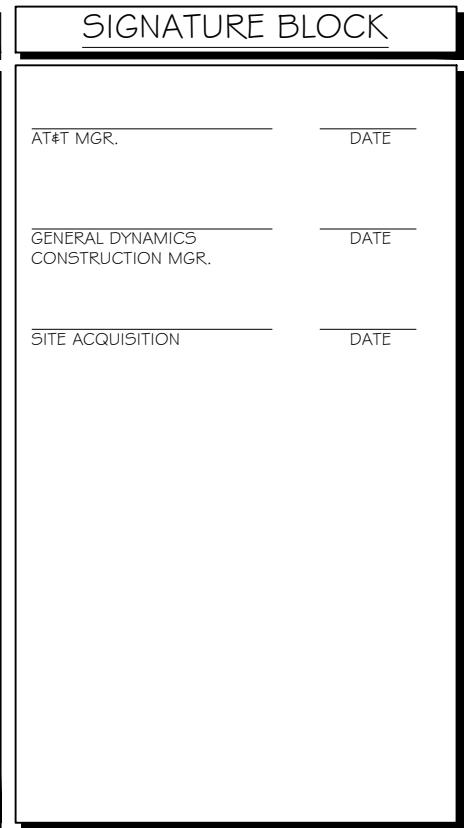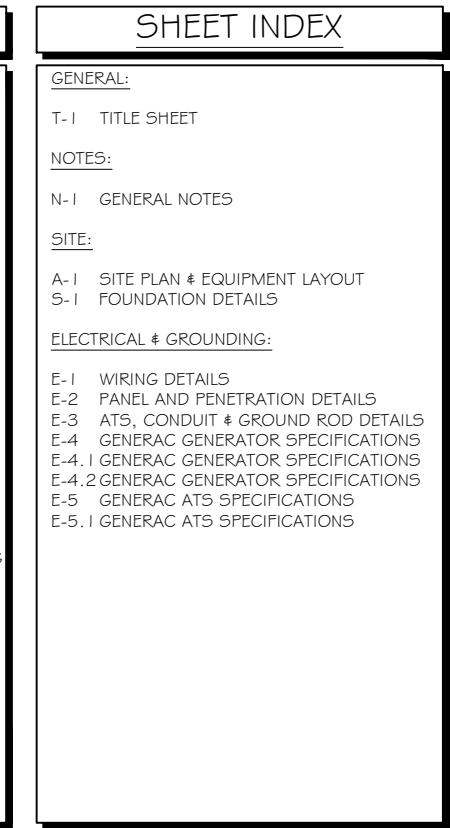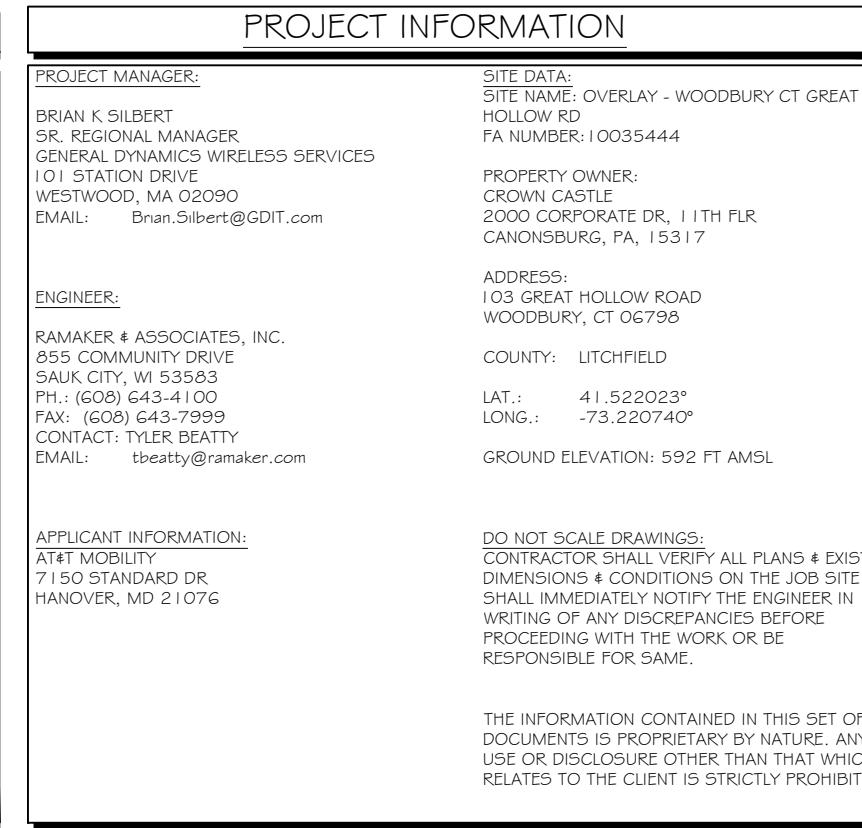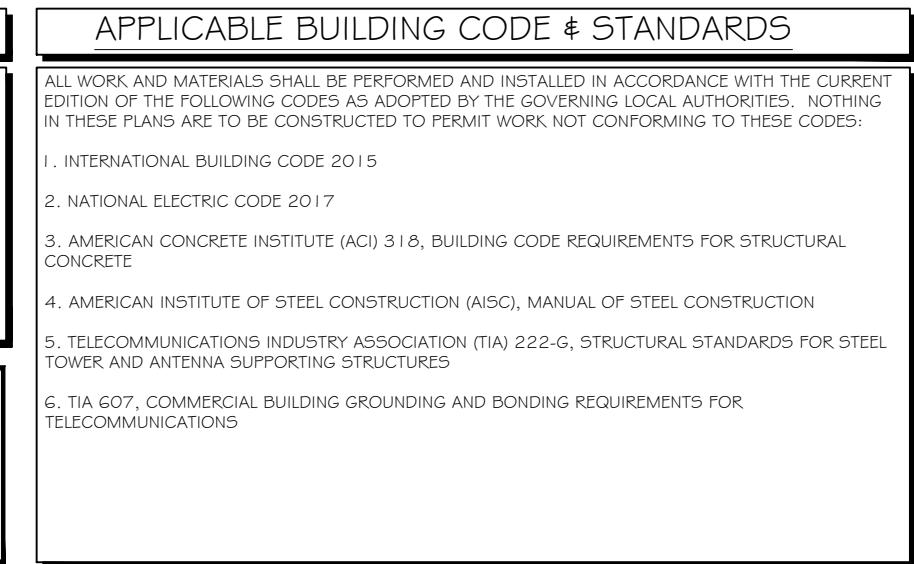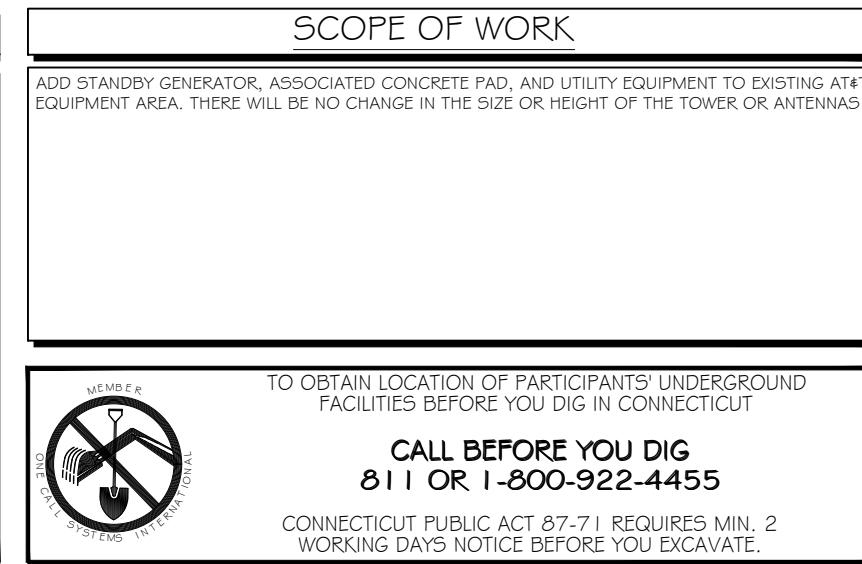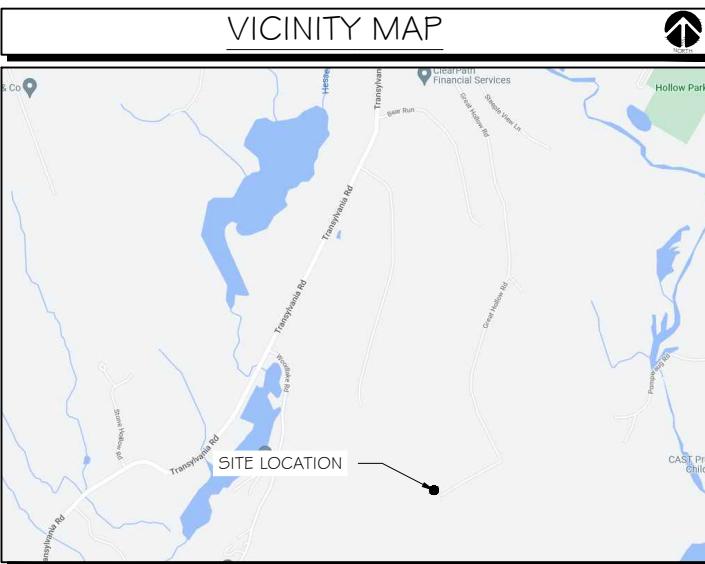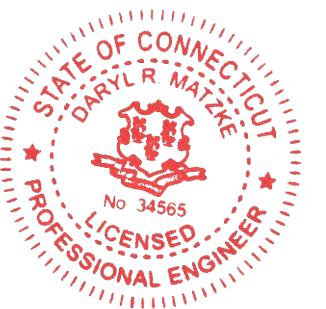

NOTES TO SUBCONTRACTOR:

1. THE GENERAL SUBCONTRACTOR MUST VERIFY ALL DIMENSIONS, CONDITIONS AND ELEVATIONS BEFORE PROCEEDING WITH THE WORK. ALL WORK SHALL BE PERFORMED IN A WORKMANLIKE MANNER IN ACCORDANCE WITH ACCEPTED CONSTRUCTION PRACTICES.
2. IT IS THE INTENTION OF THESE DRAWINGS TO SHOW THE COMPLETED INSTALLATION. THE SUBCONTRACTOR SHALL BE RESPONSIBLE FOR ALL TEMPORARY BRACING, SHORING, TIES, FORM WORK, ETC. IN ACCORDANCE WITH ALL NATIONAL, STATE, AND LOCAL ORDINANCES, TO SAFELY EXECUTE ALL WORK AND SHALL BE RESPONSIBLE FOR SAME. ALL WORK SHALL BE IN ACCORDANCE WITH LOCAL CODES.
3. THE SUBCONTRACTOR SHALL USE ADEQUATE NUMBER OF SKILLED WORKMAN WHO ARE THOROUGHLY TRAINED AND EXPERIENCED IN THE NECESSARY CRAFTS AND WHO ARE COMPLETELY FAMILIAR WITH THE SPECIFIED REQUIREMENTS AND METHOD NEEDED FOR PROPER PERFORMANCE OF THE WORK.
4. CONSTRUCTION SUBCONTRACTOR AGREES THAT IN ACCORDANCE WITH GENERALLY ACCEPTED CONSTRUCTION PRACTICES, CONSTRUCTION SUBCONTRACTOR WILL BE REQUIRED TO ASSUME SOLE AND COMPLETE RESPONSIBILITY FOR JOB SITE CONDITIONS DURING THE COURSE OF CONSTRUCTION OF THE PROJECT, INCLUDING THE SAFETY OF ALL PERSONS AND PROPERTY, THAT THIS REQUIREMENT SHALL BE MADE TO APPLY CONTINUOUSLY AND NOT BE LIMITED TO NORMAL WORKING HOURS AND CONSTRUCTION SUBCONTRACTOR FURTHER AGREES TO INDEMNIFY AND HOLD DESIGN ENGINEER HARMLESS FROM ANY AND ALL LIABILITY, REAL OR ALLEGED, IN CONNECTION WITH PERFORMANCE OF WORK ON THIS PROJECT.
5. SITE GROUNDING SHALL COMPLY WITH AT&T WIRELESS SERVICES TECHNICAL SPECIFICATIONS FOR FACILITY GROUNDING FOR CELL SITE STANDARDS, LATEST EDITION, AND COMPLY WITH AT&T TOWERS GROUNDING CHECKLIST, LATEST VERSION. WHEN NATIONAL AND LOCAL GROUNDING CODES ARE MORE STRINGENT THEY SHALL GOVERN. GROUNDING SHALL BE COMPLETED BEFORE ERECTION OF TOWER.
6. ALL WORK SHALL COMPLY WITH OSHA AND STATE SAFETY REQUIREMENTS. PROCEDURES FOR THE PROTECTION OF EXCAVATIONS, EXISTING CONSTRUCTION AND UTILITIES SHALL BE ESTABLISHED PRIOR TO FOUNDATION INSTALLATION, IF TEMPORARY LIGHTING AND MARKING IS REQUIRED BY THE FEDERAL AVIATION ADMINISTRATION (FAA), IT IS THE SUBCONTRACTOR'S RESPONSIBILITY TO MAINTAIN THE NECESSARY LIGHTS AND NOTIFY THE PROPER AUTHORITIES IN THE EVENT OF A PROBLEM.
7. ALL WORK SHALL BE ACCOMPLISHED IN ACCORDANCE WITH ALL LOCAL, STATE, AND FEDERAL CODES OR ORDINANCES. THE MOST STRINGENT CODE WILL APPLY IN THE CASE OF DISCREPANCIES OR DIFFERENCES IN THE CODE REQUIREMENTS.
8. ANY DAMAGE TO THE ADJACENT PROPERTIES WILL BE CORRECTED AT THE SUBCONTRACTOR'S EXPENSE TO THE SATISFACTION OF THE LANDOWNER AND THE ENGINEER.
9. THE COMPLETE BID PACKAGE INCLUDES THESE CONSTRUCTION DRAWINGS ALONG WITH THE SPECIFICATIONS. SUBCONTRACTOR IS RESPONSIBLE FOR REVIEW OF TOTAL BID PACKAGE PRIOR TO BID SUBMITTAL..
10. SUBCONTRACTOR SHALL VERIFY LOCATION OF ALL EXISTING UTILITIES WITHIN CONSTRUCTION LIMITS PRIOR TO CONSTRUCTION.
11. THE SUBCONTRACTOR IS RESPONSIBLE FOR MAINTAINING POSITIVE DRAINAGE ON THE SITE AT ALL TIMES. SILT AND EROSION CONTROL SHALL BE MAINTAINED ON THE DOWNSTREAM SIDE OF THE SITE AT ALL TIMES. ANY DAMAGE TO ADJACENT PROPERTIES WILL BE CORRECTED AT THE SUBCONTRACTOR'S EXPENSE.
12. CLEARING OF TREES AND VEGETATION ON THE SITE SHOULD BE HELD TO A MINIMUM. ONLY THE TREES NECESSARY FOR CONSTRUCTION OF THE FACILITIES SHALL BE REMOVED. ANY DAMAGE TO THE PROPERTY OUTSIDE THE LEASED PROPERTY SHALL BE REPAIRED BY THE SUBCONTRACTOR.
13. ALL SUITABLE BORROW MATERIAL FOR BACK FILL OF THE SITE SHALL BE INCLUDED IN THE BID. EXCESS TOPSOIL AND UNSUITABLE MATERIAL SHALL BE DISPOSED OF OFF SITE AT LOCATIONS APPROVED BY GOVERNING AGENCIES PRIOR TO DISPOSAL.
14. SEEDING AND MULCHING OF THE SITE WILL BE ACCOMPLISHED AS SOON AS POSSIBLE AFTER COMPLETION OF THE SITE DEVELOPMENT. THE SUBCONTRACTOR IS RESPONSIBLE FOR PROVIDING AND MAINTAIN AN ADEQUATE COVER OF VEGETATION OVER THE SITE FOR A ONE YEAR PERIOD.
15. PERMITS: THE SUBCONTRACTOR SHALL BE RESPONSIBLE FOR OBTAINING AND INCURRING THE COST OF ALL REQUIRED PERMITS, INSPECTIONS, CERTIFICATES, ETC.
16. RECORD DRAWINGS: MAINTAIN A RECORD OF ALL CHANGES, SUBSTITUTIONS BETWEEN WORK AS SPECIFIED AND INSTALLED. RECORD CHANGES ON A CLEAN SET OF CONTRACT DRAWINGS WHICH SHALL BE TURNED OVER TO THE CONSTRUCTION MANAGER UPON COMPLETION OF THE PROJECT.
17. THE PLANS SHOW SOME KNOWN SUBSURFACE STRUCTURES, ABOVE GROUND STRUCTURES AND/OR EXISTING UTILITIES BELIEVED TO BE IN THE WORKING AREA. IT IS THE RESPONSIBILITY OF THE SUBCONTRACTOR TO VERIFY ALL UTILITIES, PIPELINES AND OTHER STRUCTURES SHOWN OR NOT SHOWN ON THESE PLANS. THE SUBCONTRACTOR SHALL CONTACT THE LOCAL JURISDICTION'S DIGGER'S HOTLINE BEFORE DIGGING OR DRILLING. ANY DAMAGE TO EXISTING UTILITIES SHALL BE REPAIRED TO THE SATISFACTION OF THE OWNER AND ENGINEER AT THE SUBCONTRACTOR'S EXPENSE.

GENERAL NOTES:

1. THIS PROPOSAL IS FOR THE ADDITION OF A NEW GENERATOR ON A CONCRETE PAD TO AN EXISTING UNMANNED TELECOMMUNICATIONS FACILITY CONSISTING OF AN EQUIPMENT SHELTER AND TOWER.
2. THE PROPOSED FACILITY WILL BE UNMANNED AND DOES NOT REQUIRE POTABLE WATER OR SEWER SERVICE.
3. THE PROPOSED FACILITY IS UNMANNED AND IS NOT FOR HUMAN HABITAT. (NO HANDICAP

ACCESS IS REQUIRED)

4. OCCUPANCY IS LIMITED TO PERIODIC MAINTENANCE AND INSPECTION, APPROXIMATELY 2 TIMES PER MONTH BY AT&T TECHNICIANS.
5. OUTDOOR STORAGE AND SOLID WASTE CONTAINERS ARE NOT PROPOSED.
6. ALL MATERIAL SHALL BE FURNISHED AND WORK SHALL BE PERFORMED IN ACCORDANCE WITH THE PROJECT SPECIFICATIONS.
7. SUBCONTRACTOR SHALL BE RESPONSIBLE FOR REPAIRING ANY DAMAGE CAUSED BY THE CONSTRUCTION OPERATION.
8. SUBCONTRACTOR SHALL BE RESPONSIBLE FOR OBTAINING ALL PERMITS AND INSPECTION REQUIRED FOR CONSTRUCTION.
9. SUBCONTRACTOR SHALL REMOVE ALL TRASH AND DEBRIS FROM THE SITE ON A DAILY BASIS.

ELECTRICAL NOTES:

A. GENERAL

1. COORDINATE LOCATION AND POWER REQUIREMENTS OF ALL EQUIPMENT WITH AT&T AND EQUIPMENT SUPPLIER PRIOR TO INSTALLATION.
2. COORDINATE LOCATION AND REQUIREMENTS FOR ELECTRICAL AND TELEPHONE SERVICES WITH THE PROPERTY REPRESENTATIVE, AT&T AND UTILITY COMPANIES. ROUTING OF CONDUITS MAY BE MODIFIED TO MEET SITE REQUIREMENTS. EXACT CONDUIT ROUTING TO BE DETERMINED IN THE FIELD.
3. ALL WIRING AND EQUIPMENT SHOWN ON ELECTRICAL SHEETS SHALL BE FURNISHED AND INSTALLED UNDER ELECTRICAL PORTION OF CONTRACT UNLESS OTHERWISE NOTED

4. UNINTERRUPTED ELECTRICAL SERVICE FOR EXISTING EQUIPMENT SHALL BE MAINTAINED DURING THE INSTALLATION OF THE WORK DESCRIBED UNDER THESE DOCUMENTS. TEMPORARY EQUIPMENT, CABLES AND WHATEVER ELSE IS NECESSARY SHALL BE PROVIDED AS REQUIRED TO MAINTAIN ELECTRICAL SERVICE. TEMPORARY SERVICE FACILITIES, IF REQUIRED AT ANY TIME, SHALL NOT BE DISCONNECTED OR REMOVED UNTIL NEW SERVICE EQUIPMENT IS IN PROPER OPERATION. IF ANY SERVICE OR SYSTEM MUST BE INTERRUPTED, THE CONTRACTOR SHALL REQUEST PERMISSION IN WRITING STATING THE DATE, TIME, ETC. THE SERVICE WILL BE INTERRUPTED AND THE AREAS AFFECTED. THIS REQUEST SHALL BE MADE IN SUFFICIENT TIME FOR PROPER ARRANGEMENTS TO BE MADE. WRITTEN PERMISSION SHALL BE OBTAINED FROM THE OWNER BEFORE INTERRUPTING ELECTRICAL SERVICE.

5. COORDINATE NEW WORK WITH OTHER TRADES AND VERIFY EXISTING CONDITIONS TO AVOID INTERFERENCE. IN CASE OF INTERFERENCE, AT&T'S REPRESENTATIVE WILL DECIDE WHICH WORK IS TO BE RELOCATED, REGARDLESS OF WHICH WAS FIRST INSTALLED.
6. THE INSTALLATION MUST COMPLY WITH NEC AND ALL FEDERAL, STATE AND LOCAL RULES AND REGULATIONS.
7. THE DRAWINGS ARE DIAGRAMMATIC AND INDICATE THE GENERAL ARRANGEMENT OF SYSTEMS AND EQUIPMENT UNLESS OTHERWISE DEFINED BY DIMENSIONS OR DETAILS. EXACT EQUIPMENT LOCATIONS AND RACEWAY ROUTING SHALL BE GOVERNED BY ACTUAL FIELD CONDITIONS AND/OR DIRECTIONS FROM AT&T'S REPRESENTATIVE.
8. CONTRACTOR SHALL PAY ALL PERMITS AND FEES REQUIRED.

9. ALL MATERIALS SHALL BE FURNISHED AND WORK SHALL BE PERFORMED IN ACCORDANCE WITH THE APPLICABLE SECTIONS OF THE STANDARDS REFERENCED BELOW:
 - a. ANSI (AMERICAN NATIONAL STANDARDS INSTITUTE)
 - b. ASTM (AMERICAN SOCIETY FOR TESTING MATERIALS)
 - c. ETL (ELECTRICAL TESTING LABORATORY)
 - d. IEC (INSULATED CABLE ENGINEERS ASSOCIATION)
 - e. IEEE (INSTITUTE OF ELECTRICAL AND ELECTRONIC ENGINEERS)
 - f. MFBU (NATIONAL BOARD OF FIRE UNDERWRITERS)
 - g. NFSC (NATIONAL ELECTRICAL SAFETY CODE)
 - h. NEMA (NATIONAL ELECTRICAL MANUFACTURER'S ASSOCIATION)
 - i. NFPA (NATIONAL FIRE PROTECTION ASSOCIATION)
 - j. UL (UNDERWRITER'S LABORATORY)

10. CONTRACTOR SHALL REVIEW PLANS, DETAILS AND SPECIFICATIONS IN DETAIL AND ADJUST WORK TO CONFORM WITH ACTUAL SITE CONDITIONS SO THAT ELECTRICAL DEVICES AND EQUIPMENT WILL BE LOCATED AND READILY ACCESSIBLE. QUANTITIES LISTED IN MATERIAL LISTS ON THE DRAWINGS ARE FOR INFORMATION ONLY. THE CONTRACTOR SHALL PROVIDE HIS OWN TAKEOFF FOR MATERIAL QUANTITY AND TYPES BASED ON ACTUAL SITE CONDITIONS, IN ADDITION, CONTRACTOR SHALL PROVIDE ALL NECESSARY MATERIALS TO INSTALL EQUIPMENT FURNISHED BY AT&T OR ITS SUPPLIERS. ALL ITEMS NOT SPECIFICALLY MENTIONED HEREIN OR SHOWN ON THE DRAWINGS, BUT WHICH ARE OBVIOUSLY NECESSARY TO MAKE A COMPLETE WORKING INSTALLATION, SHALL BE INCLUDED.

11. THE CONTRACTOR OR BIDDER SHALL BEAR THE RESPONSIBILITY OF NOTIFYING (IN WRITING) AT&T'S REPRESENTATIVE OF ANY CONFLICTS PRIOR TO THE SUBMISSION OF CONTRACTOR'S PROPOSAL OR PERFORMANCE OF WORK, IN THE EVENT OF DISCREPANCIES THE CONTRACTOR SHALL PRICE THE MORE COSTLY OR EXTENSIVE WORK, UNLESS DIRECTED IN WRITING OTHERWISE.

12. ALL FLOORS WHERE PENETRATIONS ARE REQUIRED IN BUILDING ARE TO BE CORE DRILLED AND THEN FIREPROOFED.

B. WIRING/CONDUIT

1. PROVIDE PULL BOXES AND JUNCTION BOXES WHERE SHOWN OR AS REQUIRED BY CODE SUCH THAT NO MORE THAN THE EQUIVALENT OF FOUR QUARTER BENDS (360 DEGREES TOTAL) EXIST IN A CONDUIT RUN.
2. ALL POWER AND CONTROL/INDICATION WIRING SHALL BE TYPE THHN/THWN 800V RATED 75 DEGREES CELSIUS, UNLESS NOTED OTHERWISE.

3. SCHEDULE 80 PVC CONDUIT SHALL BE USED ABOVE GROUND, WHERE ABOVE GRADE IS DEFINED AS THE GROUND OF THE TURN-UP
4. BELL END OR TERMINAL ADAPTER MUST BE INSTALLED ON END OF PVC CONDUIT PER NEC 352.46. 300.4 F, (3)
5. CONDUIT BENDS SHALL BE MADE IN ACCORDANCE WITH NEC TABLE 346-10. NO RIGHT ANGLE DEVICE OTHER THAN STANDARD CONDUIT ELBOWS WITH 12" MINIMUM INSIDE SWEEPS FOR ALL CONDUITS 2" OR LARGER.
6. POWER WIRING SIZE SHALL NOT BE SMALLER THAN #12 AWG.
7. ALL WIRING SHALL BE COPPER. ALUMINUM WILL NOT BE ACCEPTABLE ALL POWER CIRCUITS SHALL CONTAIN A GROUND WIRE.
8. PHASE MARKINGS TO BE USED AT POWER CONDUCTOR TERMINATIONS.
9. CONTRACTOR SHALL ENSURE INTEGRITY IS MAINTAINED WHEN INSTALLING CONDUIT AND WIRING.
10. INSTALL PULL STRING IN ALL CONDUIT.

11. FOR ROOFTOP INSTALLS AND BUILD-OUTS, CONDUITS INSIDE BUILDING AND ON ROOF SHALL BE RG5, UNLESS OTHERWISE NOTED. FOR RAW LAND SITES AND CO-LOCATES, PVC SCHEDULE 80 SHALL BE UTILIZED UNLESS NOTED OTHERWISE.
12. MAINTAIN MINIMUM 1'-0" VERTICAL AND 1'-0" HORIZONTAL SEPARATIONS FROM ANY MECHANICAL GAS PIPING.
13. ALL WIRING ROUTED IN PLUMIN TO BE RATED OR IN METALLIC FLEX (LIQUIDITE) CONDUIT.

C. EQUIPMENT

1. EQUIPMENT/PARTS CONNECTED TO EXISTING PANELS, DUCTS, ETC. SHALL MATCH THE CHARACTERISTICS (A/C, V, A) OF THAT EQUIPMENT.
2. ALL ELECTRICAL EQUIPMENT OUTSIDE SHALL BE NEMA OR 3R RATED.

D. GROUNDING

1. ALL GROUND CONNECTIONS TO BUILDING SHALL BE MADE USING TWO-HOLE CONNECTORS. PROVIDE STAINLESS STEEL BOLTS AND LOCK WASHERS ON ALL MECHANICAL GROUND CONNECTIONS.
2. ALL EQUIPMENT SURFACES TO BE BONDED TO GROUNDING SYSTEM SHALL BE STRIPPED OF ALL PAINT AND DIRT. CONNECTIONS TO VARIOUS METALS SHALL BE OF A TYPE AS TO CAUSE A GALVANIC OR CORROSIVE REACTION. AREA SHALL BE REPAINTED FOLLOWING BONDING.
3. ANY METALLIC ITEM WITHIN 6' OF GROUND CONDUCTORS MUST BE CONNECTED TO THE GROUNDING SYSTEM.
4. EXTERIOR, ABOVE GRADE GROUND CONNECTIONS SHALL BE FURNISHED WITH A LIBERAL PROTECTIVE COATING OF ANTI-OXIDE COMPOUND.
5. ALL MATERIALS AND LABOR REQUIRED FOR THE GROUNDING SYSTEM AS INDICATED ON THE PLANS AND DETAILS, AND AS DESCRIBED HEREIN SHALL BE FURNISHED BY THIS CONTRACTOR UNLESS OTHERWISE NOTED.
6. EXACT LOCATION OF GROUND CONNECTION POINTS SHALL BE DETERMINED IN FIELD. ADJUST LOCATIONS INDICATED ON PLANS ACCORDING TO ACTUAL EQUIPMENT LOCATIONS TO KEEP THE GROUND CONNECTION CABLES AS SHORT AS PRACTICAL.
7. PROVIDE ALL ELECTRICAL SYSTEM AND EQUIPMENT GROUNDS AS REQUIRED BY THE CURRENT EDITION OF THE NATIONAL ELECTRIC CODE AND THE CURRENT EDITION OF THE NATIONAL ELECTRICAL SAFETY CODE. BONDING JUMPERS WITH APPROVED GROUND FITTINGS SHALL BE INSTALLED AT ALL RACEWAYS, EQUIPMENT ENCLOSURES, PULL BOXES, ETC. TO MAINTAIN GROUND CONTINUITY WHERE REQUIRED BY CODE.
8. ALL EQUIPMENT GROUND CONDUCTORS SHALL BE TIN COATED, #2 AWG COPPER UNLESS NOTED OTHERWISE ON THE DRAWINGS.
9. PROVIDE PRE AND POST GROUND TEST RESULTS, USING CLAMP-ON TESTER. TEST RESULTS SHALL BE PHOTOS WITH DIGITAL TIME AND GPS STAMPED/EMBEDDED.

E. INSPECTION/DOCUMENTATION

1. THE CONTRACTOR, UPON COMPLETION OF HIS WORK, SHALL PROVIDE AS-BUILT DRAWINGS. INFORMATION SHOULD BE GIVEN TO THE GENERAL CONTRACTOR FOR INCLUSION IN FINAL AS-BUILT SURVEY DOCUMENTS TO BE GIVEN TO THE OWNER.
2. CONTRACTOR SHALL SUPPLY DOCUMENTATION ATTESTING TO THE COMPLETE GROUND SYSTEM'S RECEIPTIVITY (MAX. 5 OHMS).
3. AN ELECTRICAL INSPECTION SHALL BE MADE BY AND INSPECTING AGENCY APPROVED BY AT&T'S REPRESENTATIVE. CONTRACTOR SHALL COORDINATE ALL INSPECTIONS AND OBTAIN POWER COMPANY APPROVAL.
4. CONTRACTOR SHALL HAVE ATS AND GENERATOR RELAY INSTALLATION AND CONNECTIONS INSPECTED BY OTHERS TO ENSURE THAT UL LISTING FOR THAT EQUIPMENT IS NOT VOIDED.




PREPARED FOR:



CONSULTANT:
GENERAL DYNAMICS
 Information Technology, Inc.

GENERAL DYNAMICS
 101 STATION DR
 WESTWOOD, MA 02090

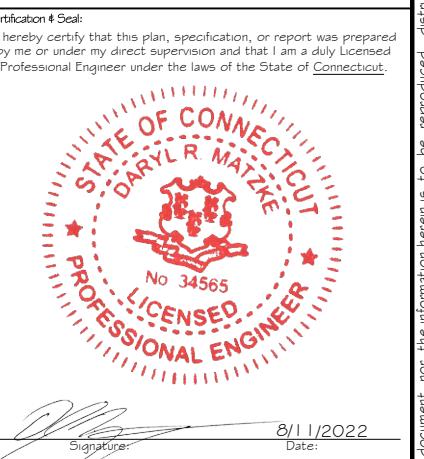

Signature: _____ Date: 8/11/2022

PROJECT TITLE: OVERLAY - WOODBURY CT GREAT HOLLOW RD FA ID # 10035444

PROJECT INFORMATION: 103 GREAT HOLLOW ROAD WOODBURY, CT 06798

SHEET TITLE: GENERAL NOTES

SCALE: NONE

PROJECT NUMBER 54172
 SHEET NUMBER N-1

SCOPE OF WORK DETAILS

GENERAL:


- NEW GENERAC DIESEL GENERATOR PROVIDED BY GENERAL DYNAMICS & INSTALLED BY GENERAL CONTRACTOR, SEE E-4.
- NEW 4'-0" X 10'-0" CONCRETE PAD PROVIDED & INSTALLED BY GENERAL CONTRACTOR (AS REQUIRED) SEE S-1
- NEW GENERAC AUTOMATIC TRANSFER SWITCH PROVIDED BY GENERAL DYNAMICS & INSTALLED BY CONTRACTOR (AS REQUIRED) SEE E-3 & E-5.
- CONTRACTOR TO VERIFY ALL EXISTING UTILITIES PRIOR TO CONSTRUCTION
- CONTRACTOR SHALL RESTORE & REPAIR ANY DAMAGED AREAS CAUSED BY CONSTRUCTION TO ORIGINAL OR BETTER CONDITION

CONDUITS:

- INSTALL PULL STRING IN EACH CONDUIT
- (1) NEW 2" AND (1) NEW 1" ELECTRICAL CONDUITS WITH CONDUCTORS TO RUN FROM NEW GENERATOR TO NEW ATS. CONDUIT PROVIDED AND INSTALLED BY GENERAL CONTRACTOR. SEE E-1, E-2 & E-3.
- (1) NEW 1" ELECTRICAL CONDUIT WITH CONDUCTORS TO RUN FROM NEW GENERATOR TO AC PANEL. CONDUIT PROVIDED & INSTALLED BY GENERAL CONTRACTOR. SEE E-1, E-2 & E-3.
- (1) NEW 1" ALARM CONDUIT & CABLING PROVIDED & INSTALLED BY GENERAL CONTRACTOR. SEE E-1, E-2 & E-3.

GROUNDING:

- NEW EXOTHERMIC CONNECTION FROM EXISTING GROUND RING TO NEW MECHANICAL CONNECTION AT GENERATOR CHASSIS. GENERAL CONTRACTOR TO VERIFY LOCATION IN FIELD. LOCATE GROUND RODS NO MORE THAN 8'-0" APART.

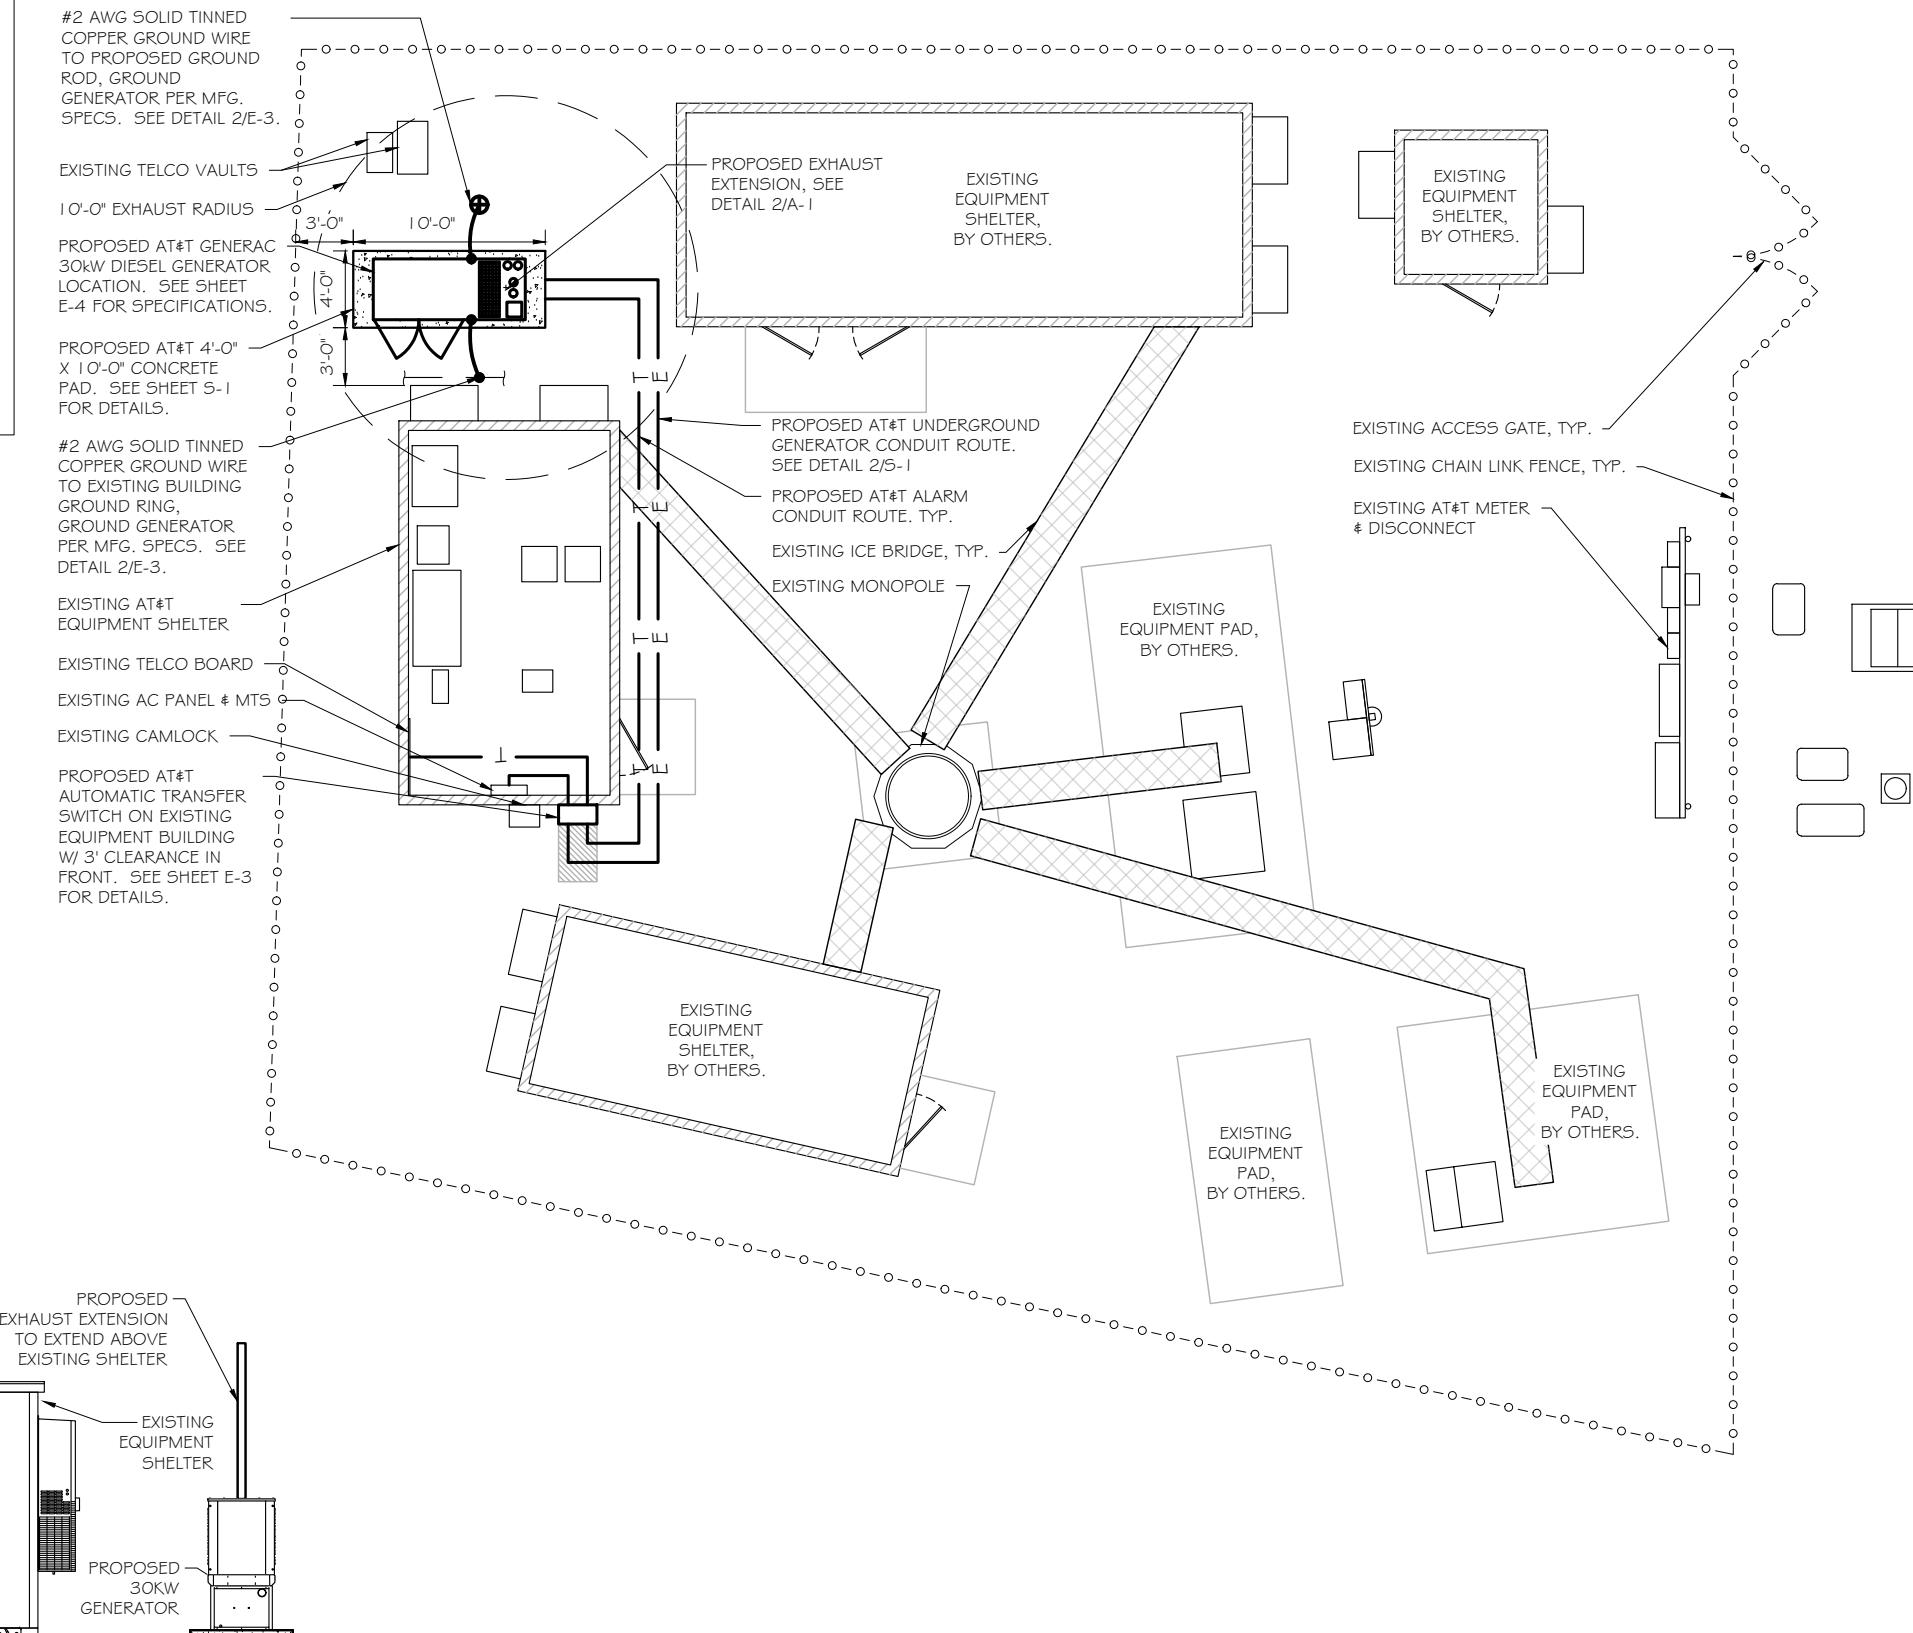

EXHAUST EXTENSION DETAIL
SCALE: NTS

SITE PLAN
SCALE: 1" = 10'




RAMAKER
employee-owned
(608) 643-4100 www.ramaker.com

PREPARED FOR:

CONSULTANT:
GENERAL DYNAMICS
Information Technology, Inc.

GENERAL DYNAMICS
101 STATION DR
WESTWOOD, MA 02090

Certification & Seal:
I hereby certify that this plan, specification, or report was prepared by me or under my direct supervision and that I am a duly licensed Professional Engineer under the laws of the State of Connecticut;

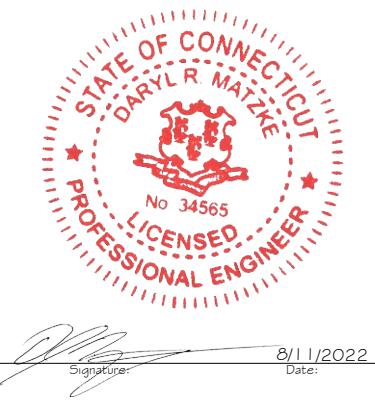



Signature: 8/11/2022 Date:

MARK DATE DESCRIPTION
ISSUE PHASE FINAL DATE ISSUED 08/11/2022
PROJECT TITLE: OVERLAY - WOODBURY CT GREAT HOLLOW RD FA ID # 10035444

PROJECT INFORMATION:
103 GREAT HOLLOW ROAD
WOODBURY, CT 06798

SHEET TITLE:
 SITE PLAN & EQUIPMENT LAYOUT

0 5' 10' 20'
11" x 17" - 1" = 10'
22" x 34" - 1" = 5'
PROJECT NUMBER 54172
SHEET NUMBER A-1

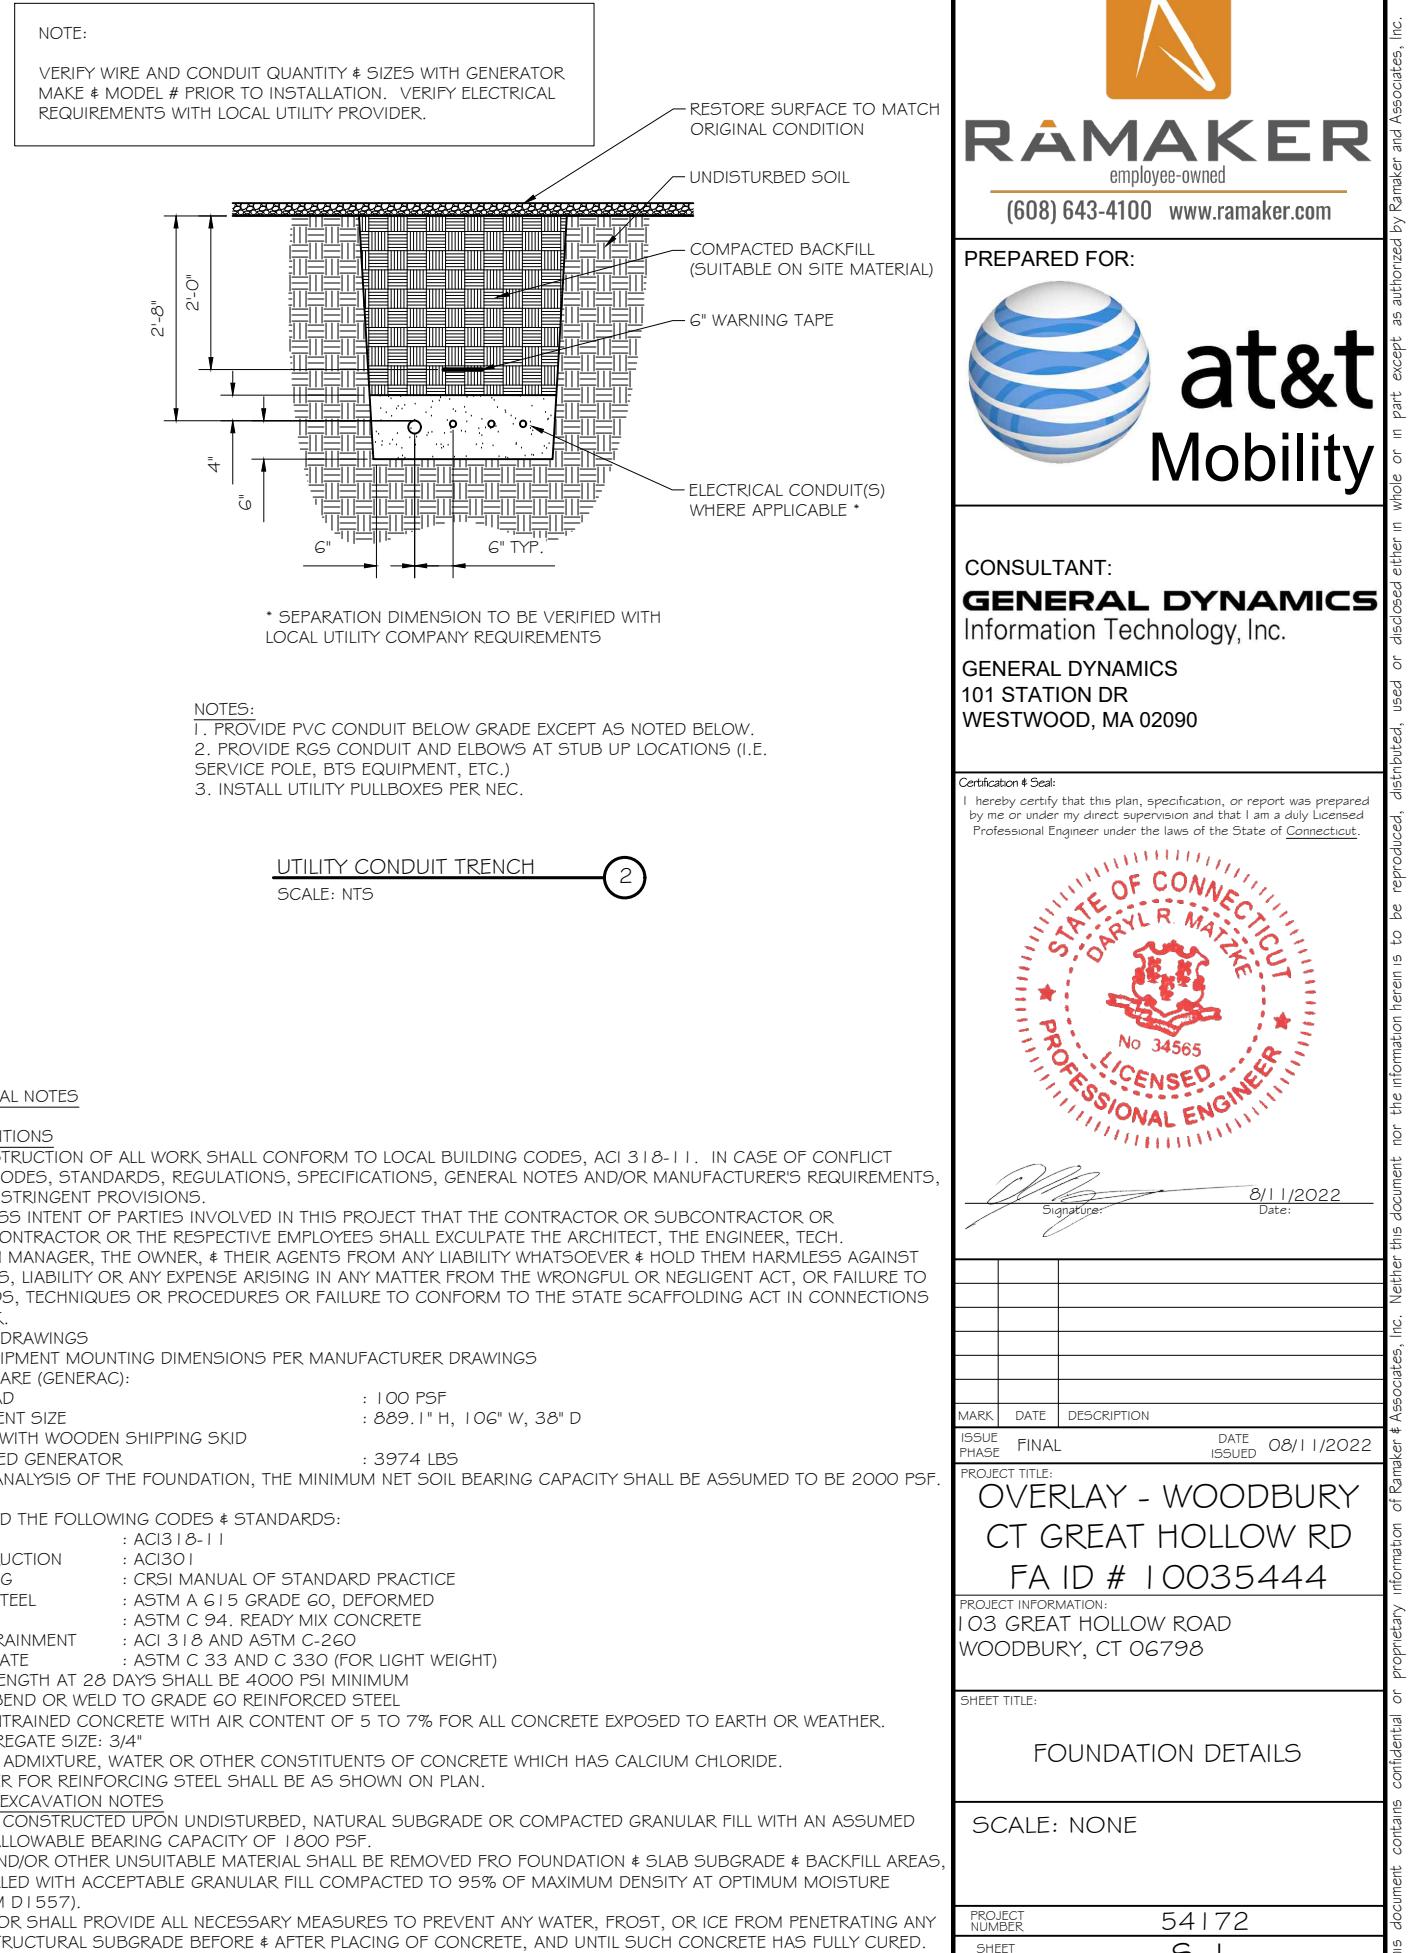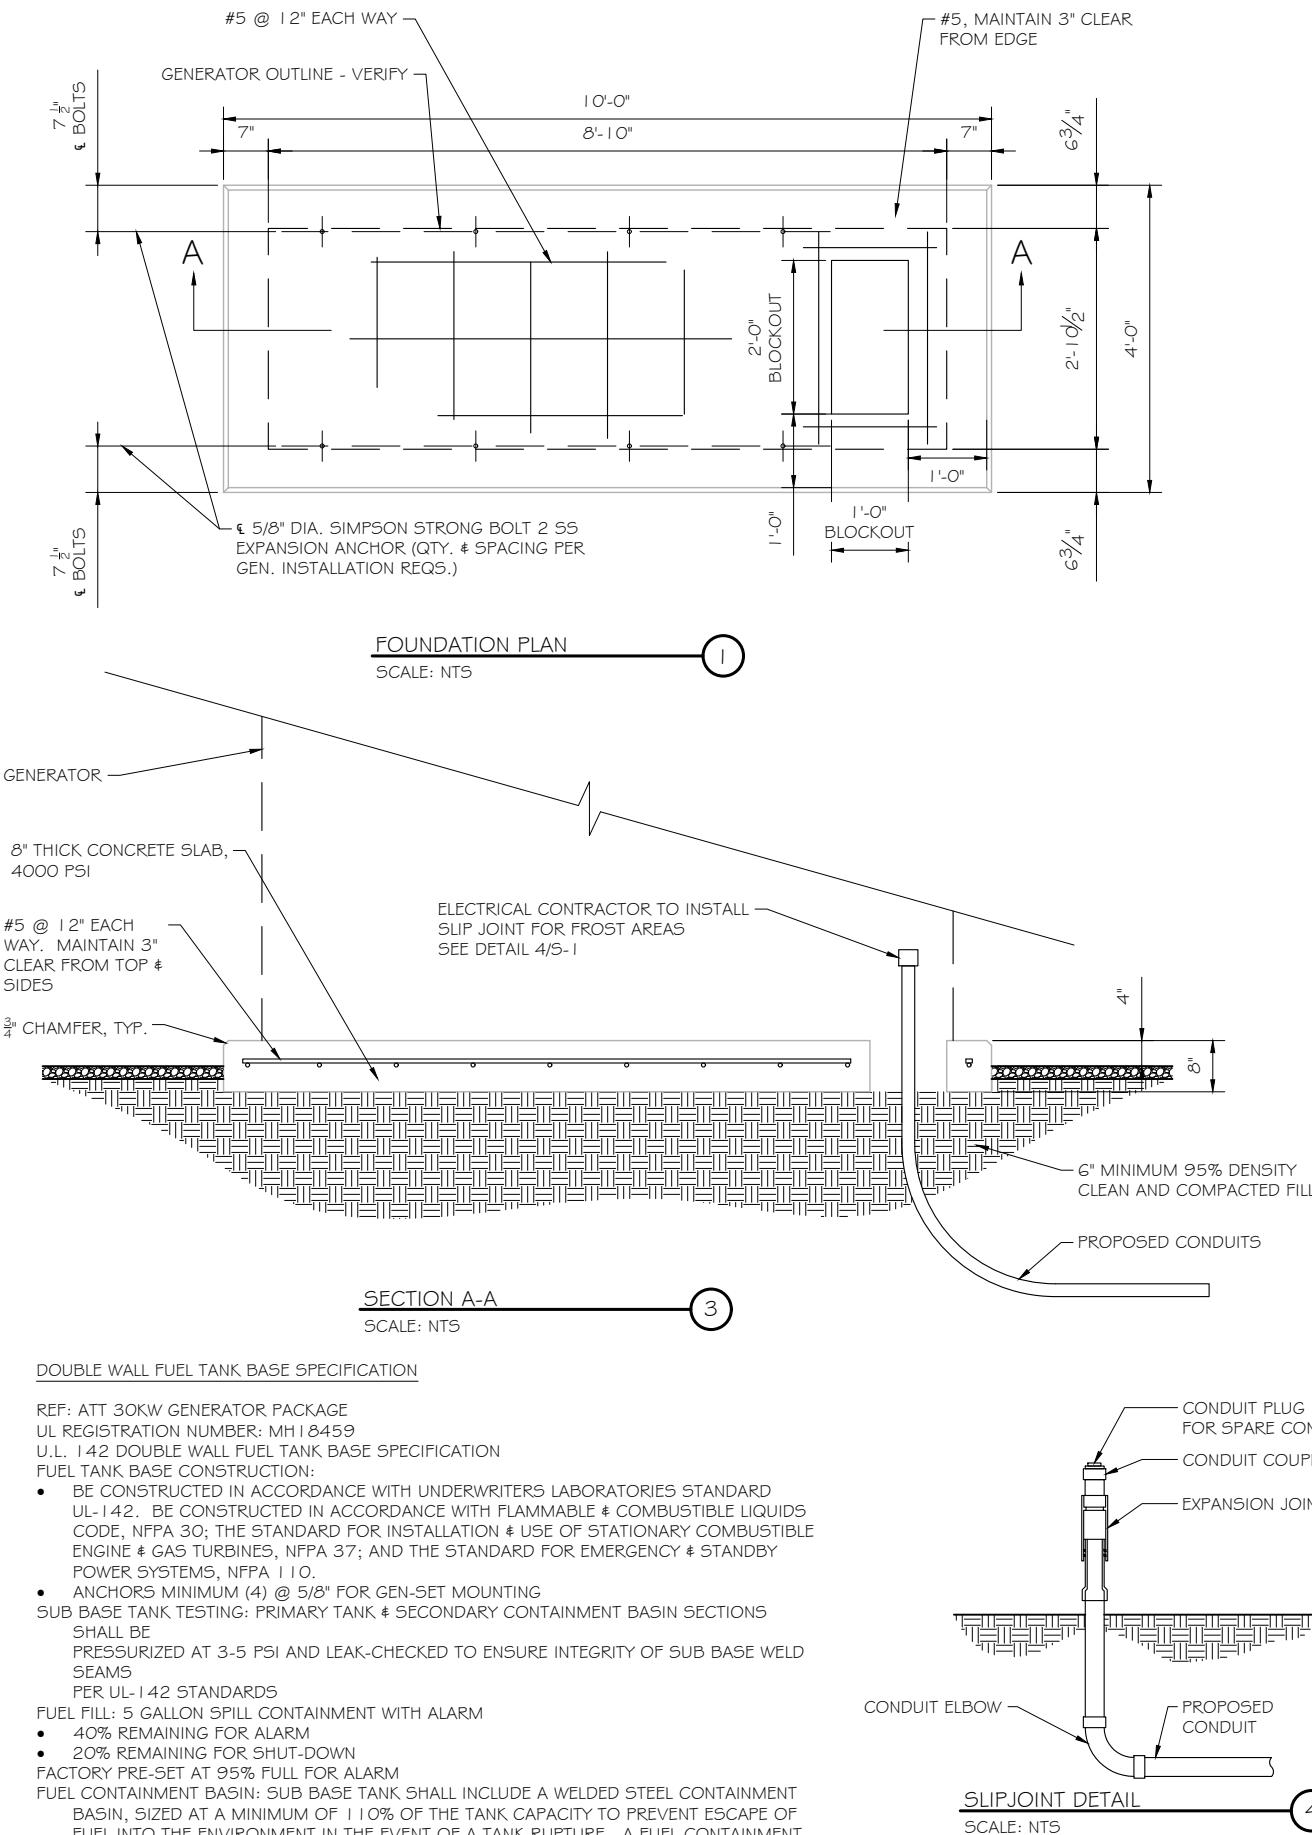

NO.	FROM	TO	WIRES	GROUND	CONDUIT SIZE	FUNCTION
1	NORMAL POWER SOURCE	AUTOMATIC TRANSFER SWITCH	(3) 3/0	(1) #4	2"	NORMAL POWER FEEDER TO ATS (CUT BACK EXISTING)
2	AUTOMATIC TRANSFER SWITCH	LOAD CENTER	(3) 3/0	(1) #4	2"	POWER FEEDER FROM ATS TO PANEL
3	GENERATOR	AUTOMATIC TRANSFER SWITCH	(3) #1	(1) #6	1-1/2"	EMERGENCY POWER FEEDER TO ATS
4	AUTOMATIC TRANSFER SWITCH	GENERATOR	(2) #10	(1) #10	1"	START CIRCUIT
5	LOAD CENTER (DISTRIBUTION CENTER)	GENERATOR, ATS	(2) #12 (2) #12 (2) #12	(1) #12 (1) #12 (1) #12	1"	CIRCUIT FOR GENERATOR BLOCK HEATER & BATTERY HEATER CIRCUIT FOR BATTERY CHARGER CIRCUIT FOR ATS
6	GENERATOR	AUTOMATIC TRANSFER SWITCH	12-PAIR 24 AWG OR 2EA 6-PAIR CAT5	N/A	1"	ALARM CABLES (1) 12 PAIR 24 AWG. PROVIDE 24" OF SLACK CABLE. FINAL PUNCH DOWN IS BY AT&T TECH. LABEL ALL WIRES
7	AUTOMATIC TRANSFER SWITCH	ALARM BLOCK	12-PAIR 24 AWG OR 2EA 6-PAIR CAT5	N/A	1"	ALARM CABLES (1) 12 PAIR 24 AWG (RUN TO PURCELL CABINET & INTO ALARM BOX). PROVIDE 24" OF SLACK CABLE. FINAL PUNCH DOWN IS BY AT&T TECH. LABEL ALL WIRES

CIRCUIT DETAIL
SCALE: NTS

1


ALARM WIRE IDENTIFICATION CHART

WIRE	ALARM
BROWN	GENERATOR RUNNING
BROWN / WHITE	
GREEN	CRITICAL FAULT
GREEN / WHITE	
BLUE	MINOR FAULT
BLUE / WHITE	
ORANGE	LOW FUEL
ORANGE / WHITE	
BROWN *	
BROWN / WHITE *	FUEL LEAK

*CAT5 CABLE ONLY, FROM 2ND CAT5 CABLE

ALARM WIRING IDENTIFICATION CHART
SCALE: NTS

2

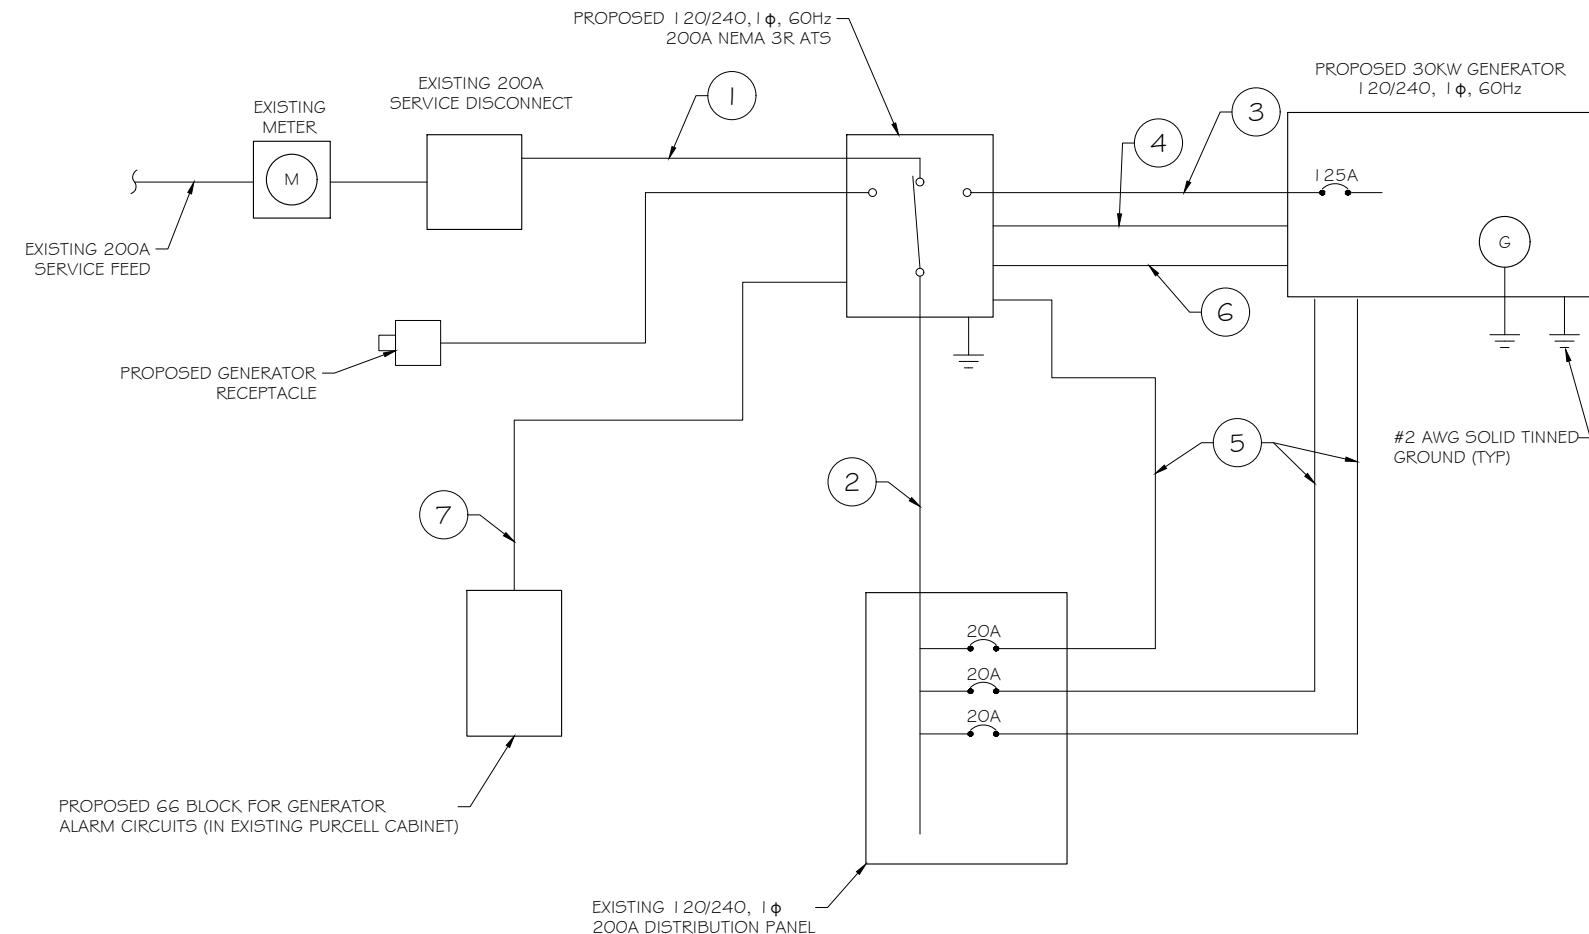

PROPOSED WIRING DIAGRAM
SCALE: NTS

3

CONSULTANT:
GENERAL DYNAMICS
Information Technology, Inc.
GENERAL DYNAMICS
101 STATION DR
WESTWOOD, MA 02090

Certification & Seal:
I hereby certify that this plan, specification, or report was prepared by me or under my direct supervision and that I am a duly licensed Professional Engineer under the laws of the State of Connecticut.



MARK DATE DESCRIPTION
ISSUE PHASE FINAL DATE ISSUED 08/11/2022

PROJECT TITLE: OVERLAY - WOODBURY
CT GREAT HOLLOW RD
FA ID # 10035444
PROJECT INFORMATION: 103 GREAT HOLLOW ROAD
WOODBURY, CT 06798

SHEET TITLE: WIRING DETAILS
SCALE: NONE


PROJECT NUMBER 54172
SHEET NUMBER E-1

AC Distribution Panel - Layout Diagram									
Breaker Position	Breaker Type	On/Off	Size	Circuit Label	Breaker Position	Breaker Type	On/Off	Size	Circuit Label
1	2P	ON	50	HVAC 1	2	1P	ON	20	
3					4	1P	ON	20	
5	1P	ON	20	INT LIGHTS	6	1P	ON	20	
7	1P	ON	20		8	2P	ON	50	HVAC 2
9	1P	ON	20	EXT LIGHTS	10				
11	2P	ON	30	RECT 1	12	2P	ON	30	RECT 4
13					14				
15	2P	ON	30	RECT 2	16	2P	ON	30	RECT 5
17					18				
19	2P	ON	30	RECT 3	20	2P	ON	30	RECT 6
21					22				
23	2P	ON	30	RECT 7	24	2P	ON	30	RECT 8
25					26				
27	2P	ON	30	RECT 9	28	1P	ON	20	
29					30	1P	ON	20	
31	1P	ON	20		32	1P	ON	20	SMOKE DET
33	1P	ON	20		34				
35					36				
37					38	1P	ON	20	ATS
39					40	1P	ON	20	BLOCK HEATER
41					42	1P	ON	20	BATTERY CHARGER

PROPOSED 20A BREAKERS FOR ATS, BLOCK HEATER
AND BATTERY CHARGER ON NEW AT&T GENERATOR

EXISTING PANEL SCHEDULE

SCALE: NTS

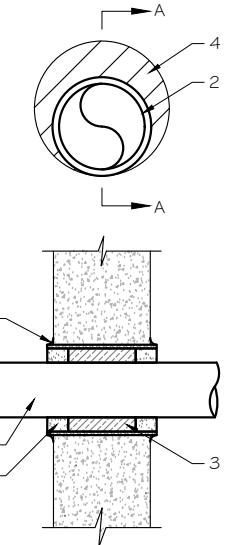

U.L. SYSTEM NO. C-AJ-1150
CONDUIT THROUGH BEARING WALL SIMILAR TO U.L. DESIGN NO. U902
F RATING = 3 HR
T RATING = 0 HR

1. FLOOR OR WALL ASSEMBLY : MINIMUM 4-1/2" THICK REINFORCED LIGHTWEIGHT OR NORMAL WEIGHT (100-150 PCF) CONCRETE. WALL MAY ALSO BE CONSTRUCTED OF ANY UL CLASSIFIED CONCRETE BLOCKS*. MAX DIAMETER OF OPENING IS 4". SEE CONCRETE BLOCKS 9CATZ) CATEGORY IN THE FIRE RESISTANCE DIRECTORY FOR NAMES OF MANUFACTURERS.
2. THROUGH PENETRATIONS : ONE METALLIC PIPE OR CONDUIT TO BE RIGIDLY SUPPORTED ON BOTH SIDES OF FLOOR OR WALL ASSEMBLY. THE ANNULAR SPACE SHALL BE MINIMUM 0". (POINT CONTACT) TO MAXIMUM 1-3/8". THE FOLLOWING TYPES AND SIZES OF METALLIC PIPES OR CONDUITS MAY BE USED:
 - A. STEEL PIPE-NOMINAL 6" DIAMETER (OR SMALLER) SCHEDULE 40 (OR HEAVIER) STEEL PIPE.
 - B. IRON PIPE-NOMINAL 6" DIAMETER (OR SMALLER) CAST OR DUCTILE IRON PIPE.
 - C. CONDUIT - NOMINAL 4" DIAMETER (OR SMALLER) STEEL ELECTRICAL METALLIC TUBING OR NOMINAL 3-1/2" DIAMETER (OR SMALLER) STEEL CONDUIT.
3. PACKING MATERIAL: MINIMUM 6" THICKNESS OF MIN 4.0 PCF MINERAL WOOL BATTING INSULATION FIRMLY PACKED INTO OPENING AS A PERMANENT FORM. PACKING MATERIAL TO BE RECESSED FROM TOP SURFACE OF FLOOR OR FROM BOTH SURFACES OF WALL AS REQUIRED TO ACCOMMODATE THE REQUIRED THICKNESS OF FILL MATERIAL.
4. FILL, VOID, OR CAVITY MATERIAL: SEALANT: MINIMUM 1/4" THICKNESS OF FILL MATERIAL APPLIED WITHIN THE ANNULUS, FLUSH WITH TOP SURFACE OF FLOOR AND WITH BOTH SURFACES OF WALL. AT THE POINT CONTACT LOCATION BETWEEN PIPE AND CONCRETE, A MINIMUM 1/2" DIAMETER BEAD OF FILL MATERIAL SHALL BE APPLIED AT THE CONCRETE/PIPE INTERFACE ON THE TOP SURFACE OF FLOOR AND ON BOTH SURFACES OF WALL. W RATING APPLIES ONLY WHEN CP6015 OR CP604 SEALANT IS USED.


NOTE:
1. IF EXISTING CONSTRUCTION VARIES FROM THIS DETAIL, AN EQUAL 3-HR U.L. PENETRATION APPROPRIATE FOR THE EXISTING WALL TYPE SHALL BE CONSTRUCTED
2. GC SHALL USE NON-SHRINKING CAULK TO WEATHERSEAL ALL PENETRATIONS INTO OR THRU SHELTER WALL.

HILTI CONSTRUCTION CHEMICALS, DIV OF HILTI INC. : CP6015, CP604, CP606, OR FS-ONE SEALANT.

* BEARING THE UL CLASSIFICATION MARK

OUTER WALL PENETRATION DETAIL (IF APPLICABLE)

SCALE: NTS

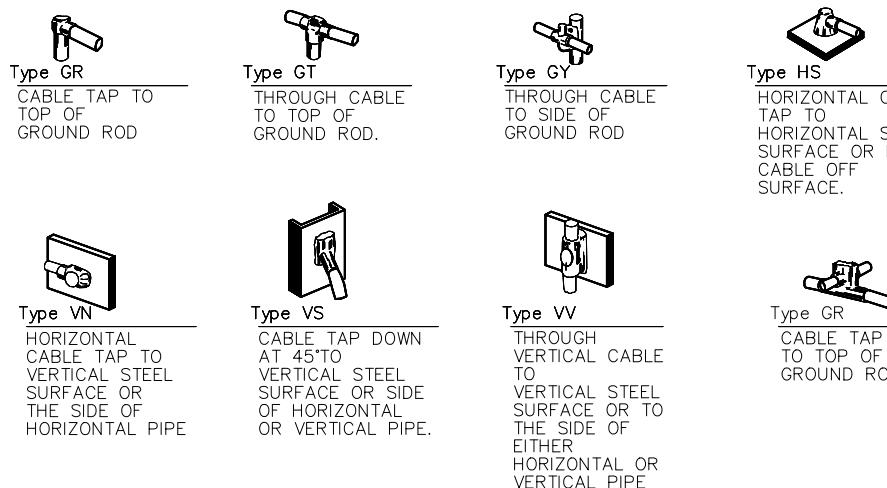

NOTE:
CONTRACTOR TO LABEL WIRES WITH P-TOUCH OR
SIMILAR LABELS ONLY. ABSOLUTELY NO
HANDWRITTEN LABELS.

*CONTRACTOR TO UTILIZE NEXT AVAILABLE IN
SEQUENCE SINGLE BREAKER POSITION FOR
GENERATOR, BATTERY CHARGER, BATTERY HEATER
AND BLOCK HEATER

CADWELD DETAILS

SCALE: NTS



PREPARED FOR:



CONSULTANT:
GENERAL DYNAMICS
Information Technology, Inc.
GENERAL DYNAMICS
101 STATION DR
WESTWOOD, MA 02090

Certification & Seal:
I hereby certify that this plan, specification, or report was prepared by me or under my direct supervision and that I am a duly licensed Professional Engineer under the laws of the State of Connecticut;




Signature: 8/11/2022
Date:
MARK DATE DESCRIPTION
ISSUE PHASE FINAL DATE ISSUED 08/11/2022
PROJECT TITLE: OVERLAY - WOODBURY
CT GREAT HOLLOW RD
FA ID # 10035444
PROJECT INFORMATION: 103 GREAT HOLLOW ROAD
WOODBURY, CT 06798

SHEET TITLE: PANEL AND PENETRATION
DETAILS
SCALE: NONE
PROJECT NUMBER: 54172
SHEET NUMBER: E-2


- 1 CONDUIT (TYP)
- 2 BUTTERFLY CLAMP AS REQUIRED
- 3 EXISTING WALL/CEILING
- 4 VERTICAL "UNISTRUT" P1000 'T' SERIES LENGTH BASED ON NUMBER OF CONDUIT TO BE MOUNTED

WALL CONSTRUCTION TYPE	USE
HOLLOW	3/8" DIA. TOGGLE BOLT
HOLLOW, AT STUD	3/8" DIA. LAG SCREW
CONCRETE BLOCK (HOLLOW)	3/8" DIA. HILTI HY-20 WITH SCREEN, MINIMUM EMBEDMENT 2-1/2"
CONCRETE (SOLID)	3/8" DIA. HILTI HY-150 WITH SCREEN, MINIMUM EMBEDMENT 2-1/2"

NOTE: USE GALVANIZED OR STAINLESS STEEL HARDWARE FOR WALL MOUNT & CONNECTIONS OF CHANNELS SPACE UNITS @ 5'-0" O.C. LENGTH OF RUN

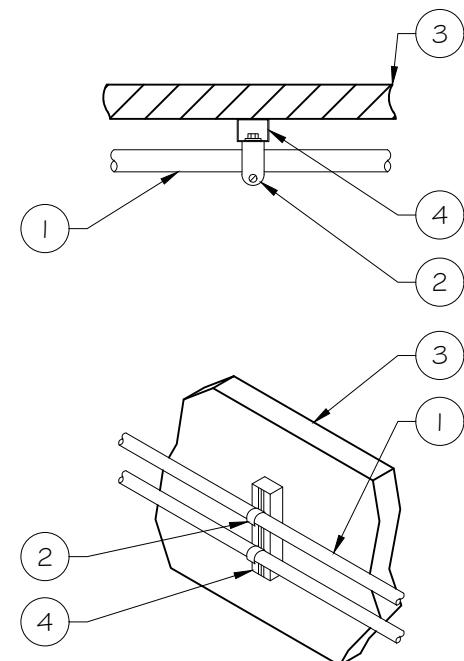

CONDUIT WALL MOUNT
SCALE: NTS

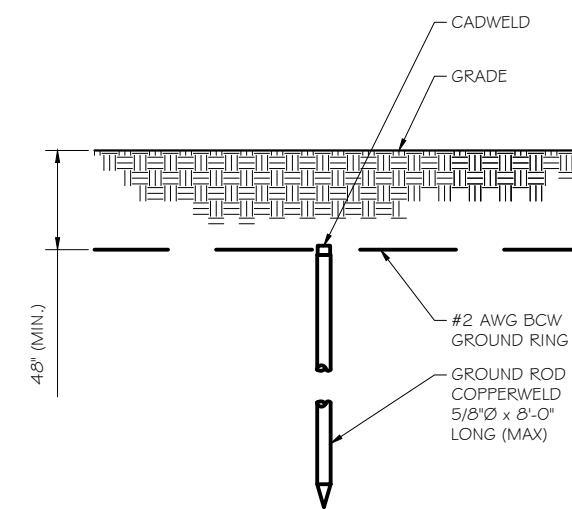


GROUND ROD DETAIL
SCALE: NTS

WALL CONSTRUCTION TYPE	USE
HOLLOW	3/8" DIA. TOGGLE BOLT
HOLLOW, AT STUD	3/8" DIA. LAG SCREW
CONCRETE BLOCK (HOLLOW)	7/16" DIA. HILTI HY-20 WITH SCREEN MINIMUM EMBEDMENT 2-1/2"
CONCRETE (SOLID)	7/16" DIA. HILTI HY-150 WITH SCREEN MINIMUM EMBEDMENT 2-1/2"

NOTE:

1. USE GALVANIZED OR STAINLESS STEEL HARDWARE FOR WALL MOUNT AND CONNECTION OF CHANNELS
2. GC SHALL USE NON-SHRINKING CAULK TO WEATHER SEAL ALL PENETRATIONS INTO OR THROUGH SHELTER WALL

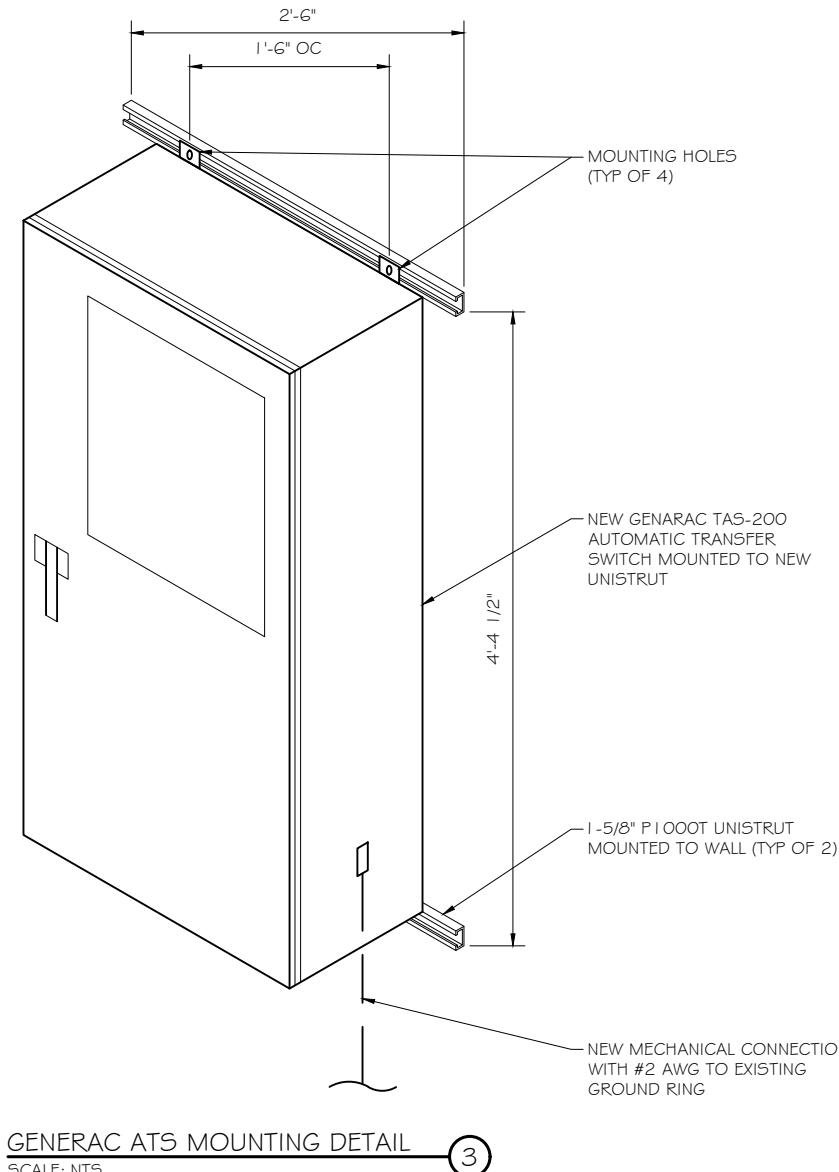

GENERAC ATS MOUNTING DETAIL
SCALE: NTS

NOTE:

1. GROUND RODS MAY BE:
 - COPPER CLAD STEEL
 - SOLID COPPER
2. GROUND RODS SHALL HAVE A MAXIMUM SPACING TWICE THE LENGTH OF ROD
3. SEE RESISTIVITY REPORT FOR VERIFICATION AS AVAILABLE
4. A LARGER CONDUCTOR SHALL BE REQUIRED IN AREAS HIGHLY PRONE TO LIGHTNING AND/OR AREAS WITH HIGHLY ACIDIC SOIL
5. GROUND RODS INSTALLED WITHIN CLOSE PROXIMITY TO TOWER OR WHEN SOIL IS AT OR BELOW 2,000 OHM-CM, SHALL BE GALVANIZED TO PREVENT GALVANIC CORROSION OF TOWER, (SEE ANSI/TIA-EIA-222-G)
6. PROVIDE (1) GROUND LEAD TO EACH SIDE OF THE GENERATOR

CONSULTANT:
GENERAL DYNAMICS
Information Technology, Inc.

GENERAL DYNAMICS
101 STATION DR
WESTWOOD, MA 02090

Certification & Seal:
I hereby certify that this plan, specification, or report was prepared by me or under my direct supervision and that I am a duly licensed Professional Engineer under the laws of the State of Connecticut.



MARK DATE DESCRIPTION
ISSUE PHASE FINAL DATE ISSUED 08/11/2022
PROJECT TITLE: OVERLAY - WOODBURY
CT GREAT HOLLOW RD
FA ID # I0035444

PROJECT INFORMATION:
I03 GREAT HOLLOW ROAD
WOODBURY, CT 06798

SHEET TITLE: ATS, CONDUIT & GROUND ROD DETAILS

SCALE: NONE

PROJECT NUMBER 54172
SHEET NUMBER E-3

RAMAKER
employee-owned
(608) 643-4100 www.ramaker.com

PREPARED FOR:


SD030 | 2.2L | 30 kW
INDUSTRIAL DIESEL GENERATOR SET

EPA Certified Stationary Emergency

Standby Power Rating
30 kW, 38 kVA, 60 Hz

Prime Power Rating*
27 kW, 34 kVA, 60 Hz



*EPA Certified Prime ratings are not available in the US or its Territories



Image used for illustration purposes only

GENERAC® INDUSTRIAL POWER

Codes and Standards

Not all codes and standards apply to all configurations. Contact factory for details.



UL2200, UL508, UL489, UL142



CSA C22.2



BS5514 and DIN 6271



SAE J1349



NFPA 37, 70, 99, 110



NEC700, 701, 702, 708



ISO 3046, 7637, 8528, 9001



NEMA ICS10, MG1, 250, ICS6, AB1



ANSI C62.41

Powering Ahead

For over 50 years, Generac has provided innovative design and superior manufacturing.

Generac ensures superior quality by designing and manufacturing most of its generator components, including alternators, enclosures and base tanks, control systems and communications software.

Generac gensets utilize a wide variety of options, configurations and arrangements, allowing us to meet the standby power needs of practically every application.

Generac searched globally to ensure the most reliable engines power our generators. We choose only engines that have already been proven in heavy-duty industrial applications under adverse conditions.

Generac is committed to ensuring our customers' service support continues after their generator purchase.

SD030 | 2.2L | 30 kW
INDUSTRIAL DIESEL GENERATOR SET

EPA Certified Stationary Emergency

STANDARD FEATURES

ENGINE SYSTEM

- Oil Drain Extension
- Air Cleaner
- Fan Guard
- Stainless Steel Flexible Exhaust Connection
- Factory Filled Oil and Coolant
- Radiator Duct Adapter (Open Set Only)
- Critical Silencer (Enclosed Unit Only)
- Engine Coolant Heater

Fuel System

- Fuel Lockoff Solenoid
- Primary Fuel Filter

Cooling System

- Closed Coolant Recovery System
- UV/Ozone Resistant Hoses
- Factory-Installed Radiator
- Radiator Drain Extension
- 50/50 Ethylene Glycol Antifreeze

Electrical System

- Battery Charging Alternator
- Battery Cables
- Battery Tray
- Rubber-Booted Engine Electrical Connections
- Solenoid Activated Starter Motor

CONTROL SYSTEM



Digital H Control Panel- Dual 4x20 Display

Program Functions

- Programmable Crank Limiter
- 7-Day Programmable Exerciser
- Special Applications Programmable Logic Controller
- RS-232/485 Communications
- All Phase Sensing Digital Voltage Regulator
- 2-Wire Start Capability
- Date/Time Fault History (Event Log)
- Isochronous Governor Control
- Waterproof/Sealed Connectors

1 of 6

SPEC SHEET

ALTERNATOR SYSTEM

- UL2200 GENprotect™
- Class H Insulation Material
- 2/3 Pitch
- Skewed Stator
- Brushless Excitation
- Sealed Bearing
- Rotor Dynamically Spin Balanced
- Amortisseur Winding (3-Phase Only)
- Full Load Capacity Alternator
- Protective Thermal Switch

GENERATOR SET

- Internal Genset Vibration Isolation
- Separation of Circuits - High/Low Voltage
- Separation of Circuits - Multiple Breakers
- Wrapped Exhaust Piping
- Standard Factory Testing
- 2 Year Limited Warranty (Standby Rated Units)
- 1 Year Limited Warranty (Prime Rated Units)
- Silencer Mounted in the Discharge Hood (Enclosed Unit Only)

CONTROL SYSTEM

- Audible Alarms and Shutdowns
- Not in Auto (Flashing Light)
- Auto/Off/Manual Switch
- E-Stop (Red Mushroom-Type)
- NFPA110 Level I and II (Programmable)
- Customizable Alarms, Warnings, and Events
- Modbus® Protocol
- Predictive Maintenance Algorithm
- Sealed Boards
- Password Parameter Adjustment Protection
- Single Point Ground
- 16 Channel Remote Trending
- 0.2 msec High Speed Remote Trending
- Alarm Information Automatically Annunciated on the Display

ALARMS AND WARNINGS

- Oil Pressure
- Coolant Temperature
- Coolant Level
- Engine Speed
- Battery Voltage
- Frequency
- Coolant Temperature
- Coolant Level
- Engine Overspeed
- Battery Voltage
- Alarms and Warnings Time and Date Stamped
- Snap Shots of Key Operation Parameters During Alarms and Warnings
- Alarms and Warnings Spelled Out (No Alarm Codes)

2 of 6

SPEC SHEET

GENERAC® INDUSTRIAL POWER

ENCLOSURE (If Selected)

- Rust-Proof Fasteners with Nylon Washers to Protect Finish
- High Performance Sound-Absorbing Material (Sound Attenuation Enclosures)
- Gasketed Doors
- Stamped Air-Intake Louvers
- Upward Facing Discharge Hoods (Radiator and Exhaust)
- Stainless Steel Lift Off Door Hinges
- Stainless Steel Lockable Handles
- RhinoCoat™ - Textured Polyester Powder Coat Paint

FUEL TANKS (If Selected)

- UL 142/ULC S601
- Double Wall
- Normal and Emergency Vents
- Sloped Top
- Sloped Bottom
- Factory Pressure Tested
- Rupture Basin Alarm
- Fuel Level
- Check Valve In Supply and Return Lines
- RhinoCoat™ - Textured Polyester Powder Coat Paint
- Stainless Steel Hardware



RAMAKER
employee-owned
(608) 643-4100 www.ramaker.com

PREPARED FOR:



CONSULTANT:
GENERAL DYNAMICS
Information Technology, Inc.
GENERAL DYNAMICS
101 STATION DR
WESTWOOD, MA 02090

Certification & Seal:
I hereby certify that this plan, specification, or report was prepared by me or under my direct supervision and that I am a duly licensed Professional Engineer under the laws of the State of Connecticut;



Signature: Date: 8/11/2022

MARK DATE DESCRIPTION DATE ISSUED 08/11/2022

ISSUE PHASE FINAL PROJECT TITLE: OVERLAY - WOODBURY CT GREAT HOLLOW RD FA ID # 10035444

PROJECT INFORMATION: 103 GREAT HOLLOW ROAD WOODBURY, CT 06798

SHEET TITLE: GENERAC 30KW GENERATOR SPECIFICATIONS

SCALE: NONE

PROJECT NUMBER 54172
SHEET NUMBER E-4

SD030 | 2.2L | 30 kW
INDUSTRIAL DIESEL GENERATOR SET

EPA Certified Stationary Emergency

CONFIGURABLE OPTIONS

ENGINE SYSTEM

- Oil Heater
- Critical Silencer (Open Set Only)
- Radiator Stone Guard
- Level 1 Fan and Belt Guards (Open Set Only)

FUEL SYSTEM

- NPT Flexible Fuel Line

ELECTRICAL SYSTEM

- 10A UL Listed Battery Charger
- Battery Warmer

ALTERNATOR SYSTEM

- Alternator Upsizing
- Anti-Condensation Heater
- Tropical Coating
- Permanent Magnet Excitation

GENERATOR SET

- Extended Factory Testing
- 8 Position Load Center
- Pad Vibration Isolation

ENGINEERED OPTIONS

ENGINE SYSTEM

- Coolant Heater Isolation Ball Valves
- Fluid Containment Pan

CONTROL SYSTEM

- Spare Inputs (x4) / Outputs (x4)
- Battery Disconnect Switch

CIRCUIT BREAKER OPTIONS

- Main Line Circuit Breaker
- 2nd Main Line Circuit Breaker
- Shunt Trip and Auxiliary Contact
- Electronic Trip Breakers

ENCLOSURE

- Weather Protected Enclosure
- Level 1 Sound Attenuation
- Level 2 Sound Attenuation
- Level 2 Sound Attenuation with Motorized Dampers
- Steel Enclosure
- Aluminum Enclosure
- Up to 200 MPH Wind Load Rating (Contact Factory for Availability)
- AC/DC Enclosure Lighting Kit
- Door Alarm Switch
- Enclosure Heater
- Damper Alarm Contacts

WARRANTY (Standby Gensets Only)

- 2 Year Extended Limited Warranty
- 5 Year Limited Warranty
- 5 Year Extended Limited Warranty
- 7 Year Extended Limited Warranty
- 10 Year Extended Limited Warranty

CONTROL SYSTEM

- NFPA 110 Compliant 21-Light Remote Annunciator
- Remote Relay Assembly (8 or 16)
- Oil Temperature Indication and Alarm
- Remote E-Stop (Break Glass-Type, Surface Mount)
- Remote E-Stop (Red Mushroom-Type, Surface Mount)
- Remote E-Stop (Red Mushroom-Type, Flush Mount)
- 100 dB Alarm Horn
- Ground Fault Annunciation
- 120V GFCI and 240V Outlets
- Remote Communication - Modem
- 10A Engine Run Relay

FUEL TANKS (Size On Last Page)

- 8 in (203.2 mm) Fill Extension
- 13 in (330.2 mm) Fill Extension
- 19 in (482.6 mm) Fill Extension
- Overfill Protection Valve
- 5 Gallon Spill Box Return Hose
- 5 Gallon Spill Box
- Tank Risers
- Fuel Level Switch and Alarm
- 12' Vent System
- Fire Rated Stainless Steel Fuel Hose

FUEL TANKS

- UL2085 Tank
- Stainless Steel Tanks
- Special Fuel Tanks
- Vent Extensions

GENERATOR SET

- Special Testing



SD030 | 2.2L | 30 kW
INDUSTRIAL DIESEL GENERATOR SET

EPA Certified Stationary Emergency

APPLICATION AND ENGINEERING DATA

ENGINE SPECIFICATIONS

General

Make	Perkins
EPA Emissions Compliance	Stationary Emergency

EPA Emissions Reference	See Emission Data Sheet
-------------------------	-------------------------

Cylinder #	4
------------	---

Type	In-Line
------	---------

Displacement - in ³ (L)	135 (2.22)
------------------------------------	------------

Bore - in (mm)	3.3 (84)
----------------	----------

Stroke - in (mm)	3.9 (100)
------------------	-----------

Compression Ratio	23.3:1
-------------------	--------

Intake Air Method	Turbocharged
-------------------	--------------

Cylinder Head	Cast Iron
---------------	-----------

Piston Type	Aluminum
-------------	----------

Crankshaft Type	Forged Steel
-----------------	--------------

Engine Governing	
------------------	--

Governor	Electronic Isochronous
----------	------------------------

Frequency Regulation (Steady State)	±0.5%
-------------------------------------	-------

Engine Electrical System

System Voltage	12 VDC
----------------	--------

Battery Charger Alternator	Standard
----------------------------	----------

Oil Pump Type	Gear
---------------	------

Oil Filter Type	Full-Flow
-----------------	-----------

Crankcase Capacity - qt (L)	11.2 (10.6)
-----------------------------	-------------

Ground Polarity	Negative
-----------------	----------

ALTERNATOR SPECIFICATIONS

Standard Model	K0035124Y21
Poles	4
Field Type	Revolving
Insulation Class - Rotor	H
Insulation Class - Stator	H
Total Harmonic Distortion	<5% (3-Phase)
Telephone Interference Factor (TIF)	< 50

Standard Excitation	Brushless
---------------------	-----------

Bearings	Single Sealed
----------	---------------

Coupling	Direct via Flexible Disc
----------	--------------------------

Load Capacity - Standby	100%
-------------------------	------

Prototype Short Circuit Test	Yes
------------------------------	-----

Voltage Regulator Type	Digital
------------------------	---------

Number of Sensed Phases	All
-------------------------	-----

Regulation Accuracy (Steady State)	±0.25%
------------------------------------	--------

GENERAC | INDUSTRIAL POWER

EPA Certified Stationary Emergency




RAMAKER
employee-owned
(608) 643-4100 www.ramaker.com

PREPARED FOR:



CONSULTANT:
GENERAL DYNAMICS
Information Technology, Inc.
GENERAL DYNAMICS
101 STATION DR
WESTWOOD, MA 02090

Certification & Seal:
I hereby certify that this plan, specification, or report was prepared by me or under my direct supervision and that I am a duly licensed Professional Engineer under the laws of the State of Connecticut:

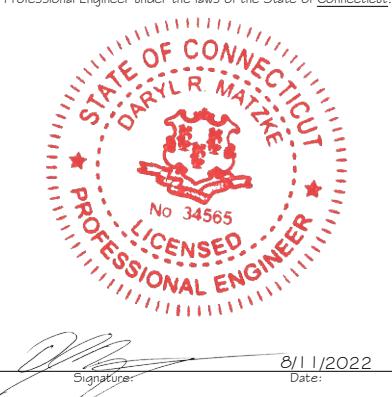

Signature: _____ Date: 8/11/2022

SD030 | 2.2L | 30 kW
INDUSTRIAL DIESEL GENERATOR SET

EPA Certified Stationary Emergency

OPERATING DATA

POWER RATINGS

Standby		
Single-Phase 120/240 VAC @1.0pf	30 kW	Amps: 125
Three-Phase 120/208 VAC @0.8pf	30 kW	Amps: 104
Three-Phase 120/240 VAC @0.8pf	30 kW	Amps: 90
Three-Phase 277/480 VAC @0.8pf	30 kW	Amps: 45
Three-Phase 346/600 VAC @0.8pf	30 kW	Amps: 36

MOTOR STARTING CAPABILITIES (skVA)

skVA vs. Voltage Dip			
277/480 VAC	30%	208/240 VAC	30%
K0035124Y21	61	K0035124Y21	46
K0040124Y21	76	K0040124Y21	58
K0050124Y21	98	K0050124Y21	75

FUEL CONSUMPTION RATES*

Diesel - gph (Lph)		
Fuel Pump Lift- ft (m)	Percent Load	Standby
3 (1)	25%	1.0 (3.7)
	50%	1.4 (5.2)
	75%	2.0 (7.5)
	100%	2.8 (10.5)
16.6 (63)		

* Fuel supply installation must accommodate fuel consumption rates at 100% load.

COOLING

Standby		
Coolant Flow	gpm (Lpm)	14.9 (56.2)
Coolant System Capacity	gal (L)	2.5 (9.5)
Heat Rejection to Coolant	BTU/hr (kW)	128,638 (136)
Inlet Air	scfm (m ³ /hr)	2,800 (4,757)
Maximum Operating Ambient Temperature	°F (°C)	122 (50)
Maximum Operating Ambient Temperature (Before Derate)	See Bulletin No. 0199280SSD	
Maximum Radiator Backpressure	in H ₂ O (kPa)	0.5 (0.12)

COMBUSTION AIR REQUIREMENTS

Standby		
Flow at Rated Power scfm (m ³ /min)	88 (2.5)	

ENGINE

Standby		
Rated Engine Speed	RPM	1,800
Horsepower at Rated kW**	hp	49
Piston Speed	ft/min (m/min)	1,181 (360)
BMEP	psi (kPa)	159 (1,096)

** Refer to "Emissions Data Sheet" for maximum bHP for EPA and SCAQMD permitting purposes.

Derate - Operational characteristics consider maximum ambient conditions. Derate factors may apply under atypical site conditions.

Please contact a Generac Power Systems Industrial Dealer for additional details. All performance ratings in accordance with ISO3046, BS5514, ISO8528, and DIN6271 standards.

Standby - See Bulletin 0187500SSB

Prime - See Bulletin 0187510SSB


GENERAC | INDUSTRIAL POWER

SD030 | 2.2L | 30 kW

INDUSTRIAL DIESEL GENERATOR SET

EPA Certified Stationary Emergency


DIMENSIONS AND WEIGHTS*

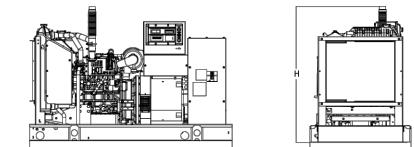

GENERAC | INDUSTRIAL POWER


INDUSTRIAL DIESEL GENERATOR SET

EPA Certified Stationary Emergency

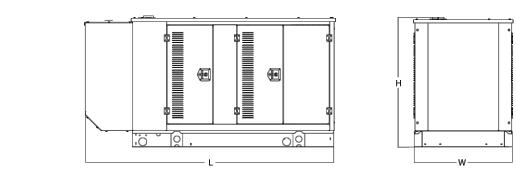


WEATHER PROTECTED ENCLOSURE

Run Time - Hours	Usable Capacity - Gal (L)	L x W x H - in (mm)	Weight - lbs (kg)
No Tank	-	94.8 (2,409) x 38.0 (965) x 49.5 (1,258)	1,641 (745)
19	54 (204)	94.8 (2,409) x 37.4 (950) x 57.8 (1,468)	2,121 (963)
47	132 (501)	76.0 (1,930) x 37.4 (950) x 69.8 (1,773)	2,351 (1,067)
75	211 (799)	76.0 (1,930) x 37.4 (950) x 81.8 (2,078)	2,560 (1,162)
107	300 (1,136)	92.9 (2,360) x 37.4 (950) x 81.8 (2,078)	2,623 (1,190)

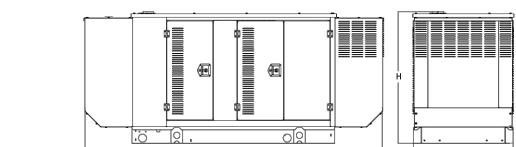

LEVEL 1 ACOUSTIC ENCLOSURE

Run Time - Hours	Usable Capacity - Gal (L)	L x W x H - in (mm)	Weight - lbs (kg)
No Tank	-	112.5 (2,857) x 38.0 (965) x 49.5 (1,258)	1,641 (745)
19	54 (204)	112.5 (2,857) x 38.0 (965) x 62.5 (1,582)	2,121 (963)
47	132 (501)	112.5 (2,857) x 38.0 (965) x 74.5 (1,893)	2,351 (1,067)
75	211 (799)	112.5 (2,857) x 38.0 (965) x 86.5 (2,198)	2,560 (1,162)
107	300 (1,136)	112.5 (2,857) x 38.0 (965) x 86.5 (2,198)	2,623 (1,190)

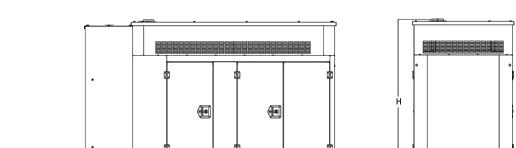

LEVEL 2 ACOUSTIC ENCLOSURE

Run Time - Hours	Usable Capacity - Gal (L)	L x W x H - in (mm)	Weight - lbs (kg)
No Tank	-	94.8 (2,407) x 38.0 (965) x 61.1 (1,551)	1,641 (745)
19	54 (204)	94.8 (2,407) x 38.0 (965) x 74.1 (1,881)	2,121 (963)
47	132 (501)	94.8 (2,407) x 38.0 (965) x 86.1 (2,186)	2,351 (1,067)
75	211 (799)	94.8 (2,407) x 38.0 (965) x 98.1 (2,491)	2,560 (1,162)
107	300 (1,136)	94.8 (2,407) x 38.0 (965) x 98.1 (2,491)	2,623 (1,190)

* All measurements are approximate and for estimation purposes only. Specification characteristics may change without notice. Please contact a Generac Power Systems Industrial Dealer for detailed installation drawings.

Generac Power Systems, Inc. | P.O. Box 8 | Waukesha, WI 53189
P: (262) 544-4811 ©2018 Generac Power Systems, Inc. All rights reserved. All specifications are subject to change without notice.

Part No. 10000024842
Rev. B 08/27/18

SPEC SHEET

5 of 6

6 of 6

7 of 7

8 of 8

9 of 9

10 of 10

11 of 11

12 of 12

13 of 13

14 of 14

15 of 15

16 of 16

17 of 17

18 of 18

19 of 19

20 of 20

21 of 21

22 of 22

23 of 23

24 of 24

TTS Series Switches

200 Amps
600 VAC



TAS200 200A Automatic Transfer Switch

TAS200
TAS200

1 of 3 2 of 3

The Generac TAS200 Automatic Transfer Switch

Flexibility for multiple application installations

Multiple generator support with 3 source panel

Designed with a 6 inch touch screen controller for improved user interface

Camlock functionality for mobile generator sources



Image used for illustration purposes only.

Features

- STEEL CONSTRUCTION
- NEMA 3R ENCLOSURE WITH HINGED "PADLOCKING" DOORS
- STAINLESS STEEL HARDWARE
- CAMLOCK "QUICK CONNECT" CAPABILITY
- OPERATIONAL STATUS VIEW VIA 6 INCH TOUCH SCREEN
- TEST FUNCTION - FAST TEST & NORMAL TEST
- UL1008 LISTED - FOR EMERGENCY SYSTEMS

Codes and Standards

Generac products are designed to the following standards:



UL1008,
UL508,
UL50,
CSA C22.2 No. 178



NEC 700, 701 and 702



NEMA 250

Optional Features

- EXTENDED WARRANTY
- THREE-PHASE VOLTAGE CONFIGURATIONS

Application and Engineering Data

Cabinet Specifications	
Dimensions	24"W x 12"D x 48"H
Weight	210 lbs.
Construction	Single Chamber with Main Door Steel UL Type / NEMA 3R Rated Powder Coat Finish for Corrosion Resistance C-UL-US Listed - Automatic Transfer Switch Stainless Steel Hardware 3-Point Latching System with Pad-Lockable Handles
Mounting Options	Wall H-frame
Installed	Pre-wired alarm terminal strip

Electrical Specifications	
Voltage/Phase/Amps	120/240 Single-Phase, 200A 120/208 3-Phase, 200A 120/240 3-Phase, 200A
Breaker	Eaton 200 amp Utility Breaker Eaton 200 amp Generator Breaker
Maximum RMS Symmetrical Fault Current - Amps	25k AIC Rated
Protective Device Continuous Rating (Max) Amp	200
Input to Generator	350MCM - #6 AWG
Output to Site	350MCM - #6 AWG
Generator Announcer Connector	Deutsch DTM04-12PA-L012
Alarm Terminal Board	Generator Run Alarm
	Generator Fail - Shutdown Alarm
	Generator Fail - Non Shutdown Alarm
	Low Fuel Alarm
	Generator Theft Alarm
	AC Utility Fail Alarm

Camlock Component	
Camlock Component	Shipped loose for multiple installation options
Dimensions	9" W x 9.4" D x 24.25" H
200A Camlock Generator Connection	Single-Phase: Black L1, Red L2, White-Neutral, Green-Ground 3-Phase: Black L1, Red L2, Blue L3, White-Neutral, Green-Ground Uses 4 CH E1016 Male Connectors Mating Connector - CH E1016 Female




PREPARED FOR:



CONSULTANT:
GENERAL DYNAMICS
Information Technology, Inc.
GENERAL DYNAMICS
101 STATION DR
WESTWOOD, MA 02090

Certification & Seal:
I hereby certify that this plan, specification, or report was prepared by me or under my direct supervision and that I am a duly licensed Professional Engineer under the laws of the State of Connecticut.

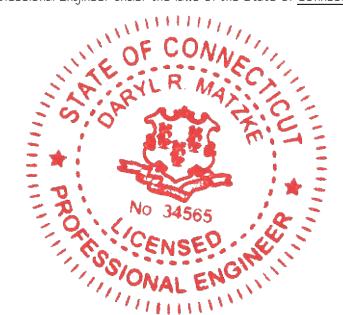

Signature: Date: 8/11/2022


MARK DATE DESCRIPTION
ISSUE PHASE FINAL DATE ISSUED 08/11/2022

PROJECT TITLE: OVERLAY - WOODBURY
CT GREAT HOLLOW RD
FA ID # 10035444
PROJECT INFORMATION: 103 GREAT HOLLOW ROAD
WOODBURY, CT 06798

SHEET TITLE: GENERAC ATS SPECIFICATIONS
SCALE: NONE

PROJECT NUMBER 54172
SHEET NUMBER E-5

Touch Screen Interface

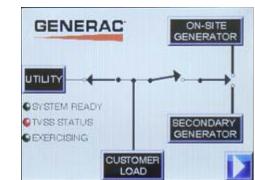

TTS Control Systems

TAS200

3 of 3

INDICATORS AND BUTTONS

<ul style="list-style-type: none">System Ready indicatorStandby Operating indicatorUtility Available indicatorGEN/UTIL Switch Position indicatorTVSS status	<ul style="list-style-type: none">Normal Test buttonFast Test buttonReturn to Normal buttonReset buttonExercising indicator
---	---

DETAILS SCREEN

System Settings: <ul style="list-style-type: none">System Voltage/Phases:<ul style="list-style-type: none">120/240V single phase (standard)120/208V three phase (optional)120/240V three phase (optional)Utility Fail Monitor:<ul style="list-style-type: none">Under Voltage: 75-95% of nominal voltageOver Voltage: 105%-125% of nominal voltagePickup (hysteresis): fixed at 5 voltsDelay time: 0-60sUtility Interrupt Delay: 0-60sReturn to Utility Timer: 1-30 minutesTransfer:<ul style="list-style-type: none">In-phase, orTime-Delay-Neutral at 0.0-10.0s in 1 second increments	Exercise Settings: <ul style="list-style-type: none">Time of dayDay of weekExercise:<ul style="list-style-type: none">Exercise with/without loadExercise once every 1, 2, or 4 weeks.Exercise time-of-dayExercise day of weekExercise duration: 15-30 minutes
Engine Settings: <ul style="list-style-type: none">Engine Warm-up timer: 0-20 minutesGenerator Load Accept:<ul style="list-style-type: none">Time-Delay-Neutral at 0.0-10.0s in 1 second incrementsVoltage: 85-95% of nominalFrequency: 85-95% of nominalEngine Minimum Run Timer: 5-30 minutesEngine Cooldown Timer: 0-20 minutes	Screen Settings: <ul style="list-style-type: none">Brightness & Contrast buttonScreen Calibration buttonStartup/Clean screen Diagnostics: <ul style="list-style-type: none">Digital I/O bits statusVoltage A/D readings Mimic Diagram: <ul style="list-style-type: none">System ReadyTransfer switch positionUtility availableStandby availableMaintenance/Auto switch positionGenerator source TS positionTVSS status

Generac Power Systems, Inc. • S45 W29290 HWY. 59, Waukesha, WI 53189 • generac.com
©2013 Generac Power Systems, Inc. All rights reserved. All specifications are subject to change without notice. Bulletin 0195670SBY-B / Printed in U.S.A. 03/13/13


PREPARED FOR:



CONSULTANT:
GENERAL DYNAMICS
Information Technology, Inc.

GENERAL DYNAMICS
101 STATION DR
WESTWOOD, MA 02090

Certification & Seal:
I hereby certify that this plan, specification, or report was prepared by me or under my direct supervision and that I am a duly licensed Professional Engineer under the laws of the State of Connecticut.

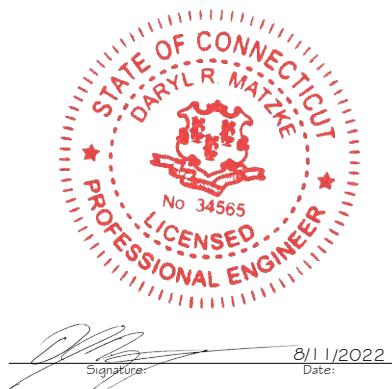

Signature: 8/11/2022
Date:
PROJECT TITLE: OVERLAY - WOODBURY
CT GREAT HOLLOW RD
FA ID # 10035444
ISSUE PHASE: FINAL DATE ISSUED: 08/11/2022

PROJECT INFORMATION: 103 GREAT HOLLOW ROAD
WOODBURY, CT 06798
SHEET TITLE: GENERAC ATS SPECIFICATIONS

SCALE: NONE
PROJECT NUMBER: 54172
SHEET NUMBER: E-5.1

ATTACHMENT 2



STATE OF CONNECTICUT

CONNECTICUT SITING COUNCIL

Ten Franklin Square, New Britain, CT 06051

Phone: (860) 827-2935 Fax: (860) 827-2950

E-Mail: siting.council@po.state.ct.us

Web Site: www.state.ct.us/csc/index.htm

June 24, 2003

TO: Parties and Intervenors

FROM: S. Derek Phelps, Executive Director

RE: **DOCKET NO. 236** - Sprint Spectrum L.P. application for a Certificate of Environmental Compatibility and Public Need for the construction, maintenance and operation of a wireless telecommunications facility off Great Hollow Road or at 103 Great Hollow Road, South Woodbury, Connecticut.

By its Decision and Order dated June 19, 2003, the Connecticut Siting Council granted a Certificate of Environmental Compatibility and Public Need for the construction, maintenance and operation of a wireless telecommunications facility located at Site A off of Great Hollow Road, Woodbury, Connecticut.

Enclosed are the Council's Findings of Fact, Opinion, and Decision and Order.

SDP/laf

Enclosures (4)

c: Albert Palko, State Documents Librarian
Council Members



STATE OF CONNECTICUT

CONNECTICUT SITING COUNCIL

Ten Franklin Square, New Britain, CT 06051

Phone: (860) 827-2935 Fax: (860) 827-2950

E-Mail: siting.council@po.state.ct.us

Web Site: www.state.ct.us/csc/index.htm

CERTIFICATE


OF

ENVIRONMENTAL COMPATIBILITY AND PUBLIC NEED

DOCKET NO. 236


Pursuant to General Statutes § 16-50k, as amended, the Connecticut Siting Council hereby issues a Certificate of Environmental Compatibility and Public Need to Sprint Spectrum, L.P. d/b/a Sprint PCS for the construction, maintenance and operation of a wireless telecommunications facility located at Site A off of Great Hollow Road, Woodbury, Connecticut. This Certificate is issued in accordance with and subject to the terms and conditions set forth in the Decision and Order of the Council on June 19, 2003.

By order of the Council,

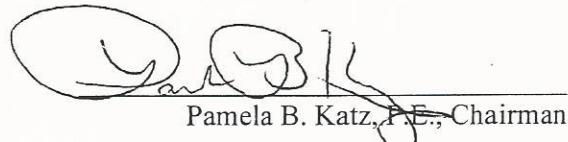

Pamela B. Katz, P.E., Chairman

June 19, 2003

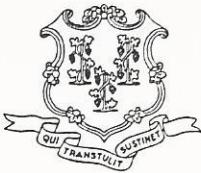

STATE OF CONNECTICUT

CONNECTICUT SITING COUNCIL

Ten Franklin Square, New Britain, CT 06051


Phone: (860) 827-2935 Fax: (860) 827-2950

E-Mail: siting.council@po.state.ct.us

Web Site: www.state.ct.us/csc/index.htm

June 24, 2003

Thomas J. Regan, Esq.
Brown Rudnick Berlack Israels LLP
185 Asylum Street, CityPlace I
Hartford, CT 06103-3402

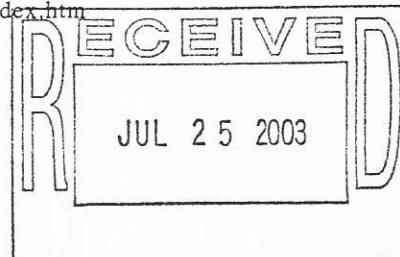

RE: **DOCKET NO. 236** - Sprint Spectrum L.P. application for a Certificate of Environmental Compatibility and Public Need for the construction, maintenance and operation of a wireless telecommunications facility off Great Hollow Road or at 103 Great Hollow Road, South Woodbury, Connecticut.

Dear Attorney Regan:

By its Decision and Order dated June 19, 2003, the Connecticut Siting Council (Council) granted a Certificate of Environmental Compatibility and Public Need for the construction, maintenance and operation of a wireless telecommunications facility at Site A off of Great Hollow Road in Woodbury to Sprint Spectrum.

Enclosed are the Council's Certificate, Findings of Fact, Opinion, and Decision and Order.

Very truly yours,

S. Derek Phelps
Executive Director

SDP/CML

Enclosures (4)

Town of Woodbury

Zoning Permit

Number 8156

Date: February 3, 2004

Permission granted to: O & G Ind. (owner) / Peter Maxwell (agent)

To Construct: Telecommunications facilities

Address: Great Hollow Road

District OS-80

Map 34

Lot 15

Set back distance from lot lines

Front: N/A

Right Side: N/A

Left Side: N/A


Rear: N/A

A-2 Requirements

Foundation *N/A* Final *N/A* Both Required

Reviewed and approved: *Judi Lynch, Land Use Administrator*

Michele DeLoach, Town Planner

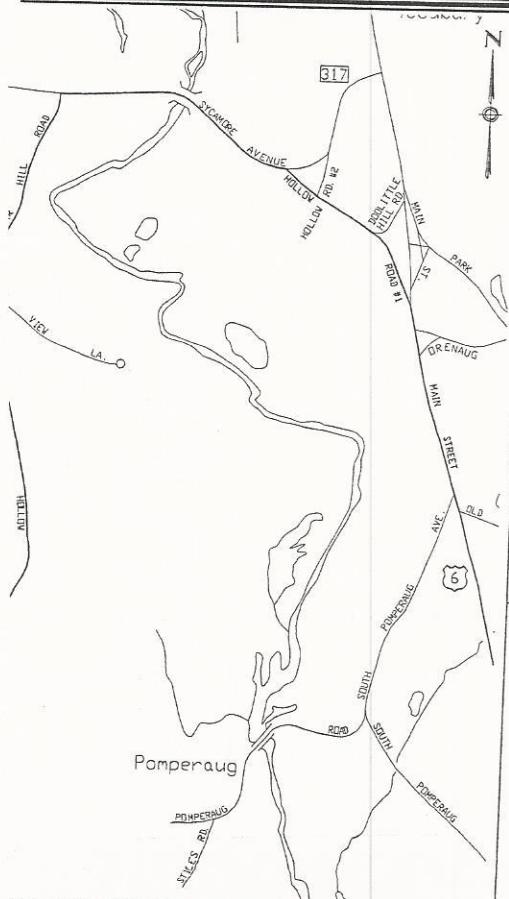

PROPERTY OWNER: ROBERT CHASE, TRUSTEE
C/O O&G INDUSTRIES
WOODBURY, CT

PROPERTY LESSEE: SPRINT SITES USA
535 EAST CRESCENT AVENUE
RAMSEY, NEW JERSEY 07446

APPLICANT/SUBLESSEE: AT&T WIRELESS PCS LLC
12 OMEGA DRIVE
STAMFORD, CONNECTICUT 06902

LATITUDE: 41.52201° (NAD 83)
LONGITUDE: 73.22074° (NAD 83)
ELEVATION: 590' AMSL
JURISDICTION: TOWN OF WOODBURY, CONNECTICUT

CURRENT USE: TELECOMMUNICATIONS FACILITY
PROPOSED USE: TELECOMMUNICATIONS FACILITY

SITE QUALIFICATION PARTICIPANTS

	NAME	COMPANY	NUMBER
A/E	IGNACIO C ARTAIZ	URS CORPORATION AES	(860) 529-8882
SAC	HOLLIS REDDING	OPTASITE, INC.	(860) 657-1460
RF	KUMAR RUGHOOBUR	BECHTEL	(203) 630-9930
QCN	ALI HEMMATI	BECHTEL	(201) 707-8161
LANDLORD	RUSS VAN OUDENAREN	SPRINT SITES USA	(201) 995-4023
OTHER			

0 10/01/03	ISSUED FOR CONSTRUCTION	JCF	10/01/03
A 09/16/03	100% REVIEW		

*STATE OF CONNECTICUT
MICHAELE DELOACH, TOWN PLANNER*

URS CORPORATION AES

TITLE SHEET

Town of Woodbury

Date: 1/30/04

Zoning Permit Number 8156

Address of property: Great Hollow Road

Map No. 34 Lot No. 15 Subdivision Name: _____

Name of Owner: O & G Industries Phone Number: 860-499-9261

Address of Owner: 112 Wall Street

DESCRIPTION OF WORK PROPOSED

concrete pad & telecommunications equipment cabinets within existing fenced enclosure; antennas on existing monopole

Size of structure: _____ Height of structure: 110'

Square footage: _____ Number of stories: _____

Type of construction: 100x100 SF lease area

Zone: R-40 OS-60 OS-80 OS-100 GA MSD PI EE MQ

Width of lot: _____ Depth of lot: _____ Total Acreage: _____

Setback distances from property lines

Front yard: 223 Rear yard: _____

Right side yard: NA Left side yard: _____

Name of Agent: Peter H. Maxwell Phone Number: 860-202-0219

Address of Agent: URS Corp, 795 Brook St, Bldg 5, Rocky Hill, CT 06067

Please Note:

An agent must provide an approval letter from the owner of the subject property before application will be approved.

Check all applicable

Is this property in the Historic District?

Yes No

Does this application involve any grading or filling?

Yes No

Will there be construction in or within 100 feet of a wetland/watercourse?

Yes No

Will this require approval from the Pomperaug Health District

Yes No

Other _____

 
Signature of Owner/Agent: Mark Deller

Approved by: Mark Deller

Date: 2-3-04

Please Note

This issued permit is based upon the plot plan submitted. Falsification by misrepresentation or omission, or failure to comply with the conditions of approval of this permit shall constitute a violation of the Town of Woodbury Zoning Regulations.



Town of Woodbury, CT

Property Listing Report

Map Block Lot

034-015

Building #

Unique Identifier

45300

Property Information

Property Location	202 GREAT HOLLOW RD		
Mailing Address	112 WALL STREET TORRINGTON CT 06790		
Land Use	Residential		
Zoning Code	OS80		
Neighborhood	22		

Owner	O & G INDUSTRIES INC
Co-Owner	
Book / Page	360/ 104
Land Class	Vacant Land
Census Tract	3621
Acreage	210.3

Valuation Summary

(Assessed value = 70% of Appraised Value)

Item	Appraised	Assessed
Buildings	0	0
Outbuildings	332302	232610
Land	1869813	191400
Total	2202115	0

Utility Information

Electric	No
Gas	No
Sewer	No
Public Water	No
Well	No



Primary Construction Details


Year Built	
Building Desc.	
Building Style	
Stories	
Exterior Walls	
Exterior Walls 2	
Interior Walls	
Interior Walls 2	
Interior Floors 1	
Interior Floors 2	

Heating Fuel	
Heating Type	
AC Type	
Bedrooms	
Full Bathrooms	
Half Bathrooms	
Extra Fixtures	
Total Rooms	
Bath Style	
Kitchen Style	
Occupancy	

Building Use	
Building Condition	
Frame Type	
Fireplaces	
Bsmt Gar	
Fin Bsmt Area	
Fin Bsmt Quality	
Building Grade	
Roof Style	
Roof Cover	

Report Created On

 8/12/2022



Town of Woodbury, CT

Property Listing Report

Map Block Lot

034-015

Building #

Unique Identifier

45300

Detached Outbuildings

Type	Description	Area (sq ft)	Condition	Year Built
Cell Towers	Fencing	600	Average	2010
Cell Towers	Pad	160	Average	2010
Cell Towers	Building/Equipment	300	Average	2010
Cell Towers	Building/Equipment	64	Average	2010
Cell Towers	Pad	200	Average	2002
Cell Towers	Building/Equipment	160	Average	2010
Cell Towers	Mono Pole	150	Average	2002
Cell Towers	Building/Equipment	200	Average	2010

Attached Extra Features



Sales History

Owner of Record	Book/ Page	Sale Date	Sale Price
O & G INDUSTRIES INC	360_104	3/20/2008	0
CHASE ROBERT L-TTEE	241_210	5/28/1999	0

Town of Woodbury, Connecticut - Assessment Parcel Map

Parcel: 034-015

Address: 202 GREAT HOLLOW RD

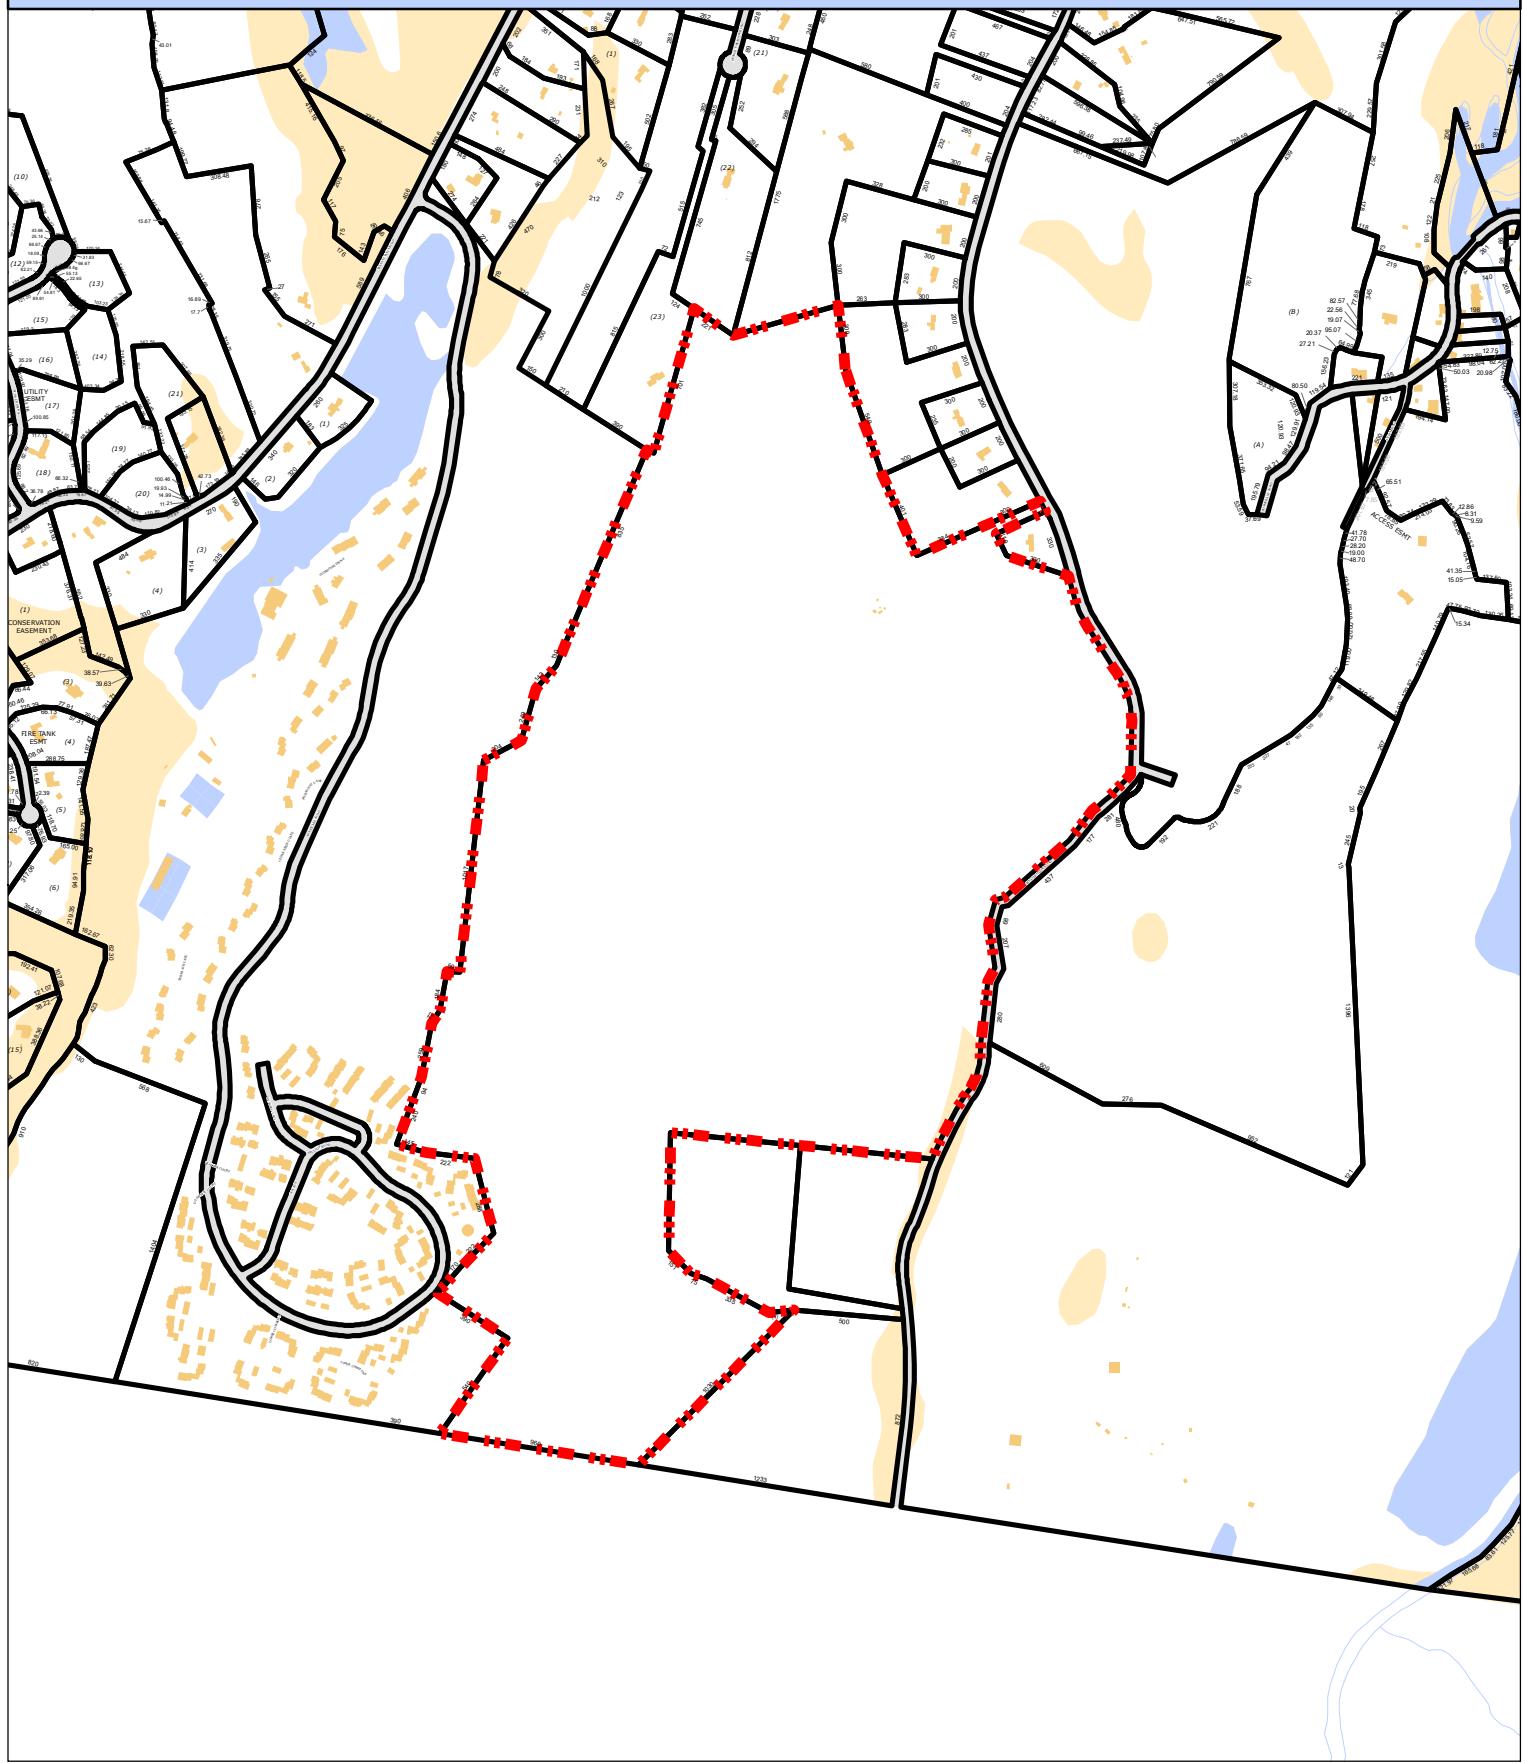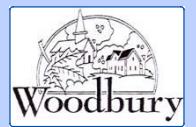

Approximate Scale: 1 inch = 900 feet

0 470 940 1,410 1,880
Feet

Disclaimer: This map is for informational purposes only.
All information is subject to verification by any user.

The Town of Woodbury and its mapping contractors assume no
legal responsibility for the information contained herein.



Map Produced:

7/12/2022

ATTACHMENT 3

ORIGIN ID:TKAA (609) 929-4735
STEVEN VOLKERT ACTW/GT: 0.50 LB
GENERAL DYNAMICS INFO TECH CAD: 105486753/NET4490
145 PROSPECT STREET
MERCHANTVILLE, NJ 08109
UNITED STATES

SHIP DATE: 17AUG22
ACTW/GT: 0.50 LB
CAD: 105486753/NET4490

BILL SENDER

TO **BARBARA PERKINSON FIRST SELECTMAN**

TOWN OF WOODBURY

281 MAIN ST SOUTH

WOODBURY CT 06798



(203) 263-2141

REF:

INV:

PO:

DEPT:

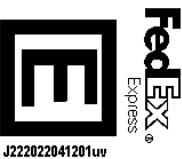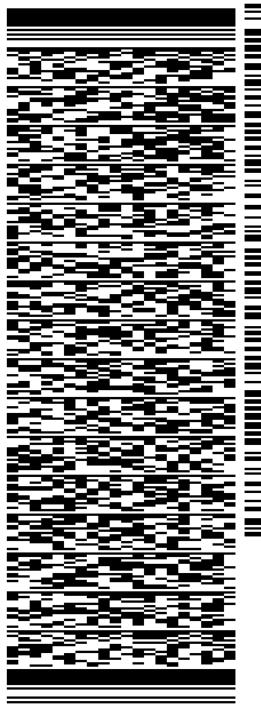


581J2/F39D/FE2D

TRK# 7776 8288 8224
0201

THU - 18 AUG 10:30A
PRIORITY OVERNIGHT

EB HFDA

06798
CT-US
BDL

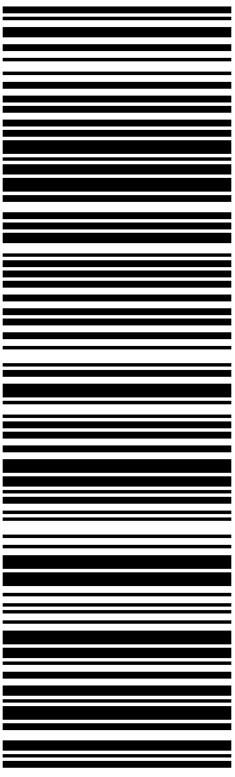

After printing this label:

1. Use the 'Print' button on this page to print your label to your laser or inkjet printer.
2. Fold the printed page along the horizontal line.
3. Place label in shipping pouch and affix it to your shipment so that the barcode portion of the label can be read and scanned.

Warning: Use only the printed original label for shipping. Using a photocopy of this label for shipping purposes is fraudulent and could result in additional billing charges, along with the cancellation of your FedEx account number.

Use of this system constitutes your agreement to the service conditions in the current FedEx Service Guide, available on fedex.com. FedEx will not be responsible for any claim in excess of \$100 per package, whether the result of loss, damage, delay, non-delivery, misdelivery, or misinformation, unless you declare a higher value, pay an additional charge, document your actual loss and file a timely claim. Limitations found in the current FedEx Service Guide apply. Your right to recover from FedEx for any loss, including intrinsic value of the package, loss of sales, income interest, profit, attorney's fees, costs, and other forms of damage whether direct, incidental, consequential, or special is limited to the greater of \$100 or the authorized declared value. Recovery cannot exceed actual documented loss. Maximum for items of extraordinary value is \$1,000, e.g. jewelry, precious metals, negotiable instruments and other items listed in our Service Guide. Written claims must be filed within strict time limits, see current FedEx Service Guide.



August 18, 2022

Dear Customer,

The following is the proof-of-delivery for tracking number: 777682888224

Delivery Information:

Status:	Delivered	Delivered To:
Signed for by:	Signature release on file	Delivery Location:
Service type:	FedEx Priority Overnight	
Special Handling:	Deliver Weekday	WOODBURY, CT,
		Delivery date: Aug 18, 2022 09:51

Shipping Information:

Tracking number:	777682888224	Ship Date:	Aug 17, 2022
		Weight:	0.5 LB/0.23 KG
Recipient:		Shipper:	
WOODBURY, CT, US,		MERCHANTVILLE, NJ, US,	

Proof-of-delivery details appear below; however, no signature is available for this FedEx Express shipment because a signature was not required.

Thank you for choosing FedEx

ORIGIN ID:TKAA (609) 929-4735
STEVEN VOLKERT ACTW/GT: 0.50 LB
GENERAL DYNAMICS INFO TECH CAD: 105486753/NET4490
145 PROSPECT STREET
MERCHANTVILLE, NJ 08109
UNITED STATES

SHIP DATE: 17AUG22
ACTW/GT: 0.50 LB
CAD: 105486753/NET4490

BILL SENDER

TO **WOODBURY PLANNING BOARD**

TOWN OF LWOODBURY

281 MAIN ST SOUTH

WOODBURY CT 06798



(203) 263-2141

REF:

INV:

PO:

DEPT:

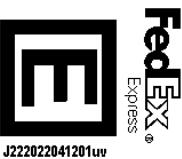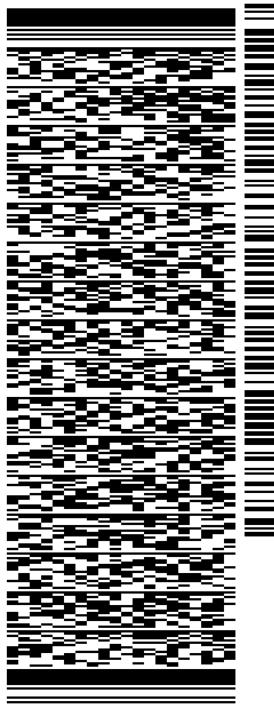


581J2/F39D/FE2D

TRK# 7776 8295 0716
0201

THU - 18 AUG 10:30A
PRIORITY OVERNIGHT

EB HFDA

06798
CT-US
BDL

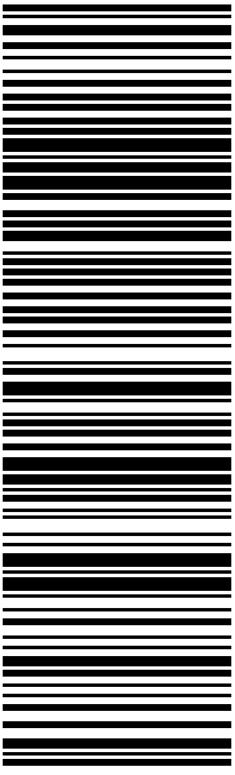

After printing this label:

1. Use the 'Print' button on this page to print your label to your laser or inkjet printer.
2. Fold the printed page along the horizontal line.
3. Place label in shipping pouch and affix it to your shipment so that the barcode portion of the label can be read and scanned.

Warning: Use only the printed original label for shipping. Using a photocopy of this label for shipping purposes is fraudulent and could result in additional billing charges, along with the cancellation of your FedEx account number.

Use of this system constitutes your agreement to the service conditions in the current FedEx Service Guide, available on fedex.com. FedEx will not be responsible for any claim in excess of \$100 per package, whether the result of loss, damage, delay, non-delivery, misdelivery, or misinformation, unless you declare a higher value, pay an additional charge, document your actual loss and file a timely claim. Limitations found in the current FedEx Service Guide apply. Your right to recover from FedEx for any loss, including intrinsic value of the package, loss of sales, income interest, profit, attorney's fees, costs, and other forms of damage whether direct, incidental, consequential, or special is limited to the greater of \$100 or the authorized declared value. Recovery cannot exceed actual documented loss. Maximum for items of extraordinary value is \$1,000, e.g. jewelry, precious metals, negotiable instruments and other items listed in our Service Guide. Written claims must be filed within strict time limits, see current FedEx Service Guide.



August 18, 2022

Dear Customer,

The following is the proof-of-delivery for tracking number: 777682950716

Delivery Information:

Status:	Delivered	Delivered To:
Signed for by:	Signature release on file	Delivery Location:
Service type:	FedEx Priority Overnight	
Special Handling:	Deliver Weekday	WOODBURY, CT,
		Delivery date: Aug 18, 2022 09:51

Shipping Information:

Tracking number:	777682950716	Ship Date:	Aug 17, 2022
		Weight:	0.5 LB/0.23 KG
Recipient:		Shipper:	
WOODBURY, CT, US,		MERCHANTVILLE, NJ, US,	

Proof-of-delivery details appear below; however, no signature is available for this FedEx Express shipment because a signature was not required.

Thank you for choosing FedEx

ORIGIN ID:TKAA (609) 929-4735
STEVEN VOLKERT ACTW/GT: 0.50 LB
GENERAL DYNAMICS INFO TECH CAD: 105486753/NET4490
145 PROSPECT STREET

MERCHANTVILLE, NJ 08109
UNITED STATES

SHIP DATE: 17AUG22
ACTW/GT: 0.50 LB
CAD: 105486753/NET4490

BILL SENDER

TO O & G INDUSTRIES INC
O & G INDUSTRIES INC
112 WALL STREET

TORRINGTON CT 06790



(318) 642-6190

REF:

INV:

PO:

DEPT:

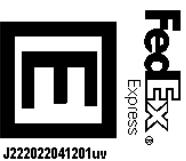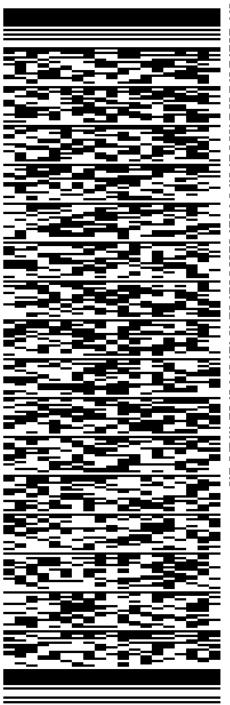

J222022041201uv

581J2/F39D/FE2D


THU - 18 AUG 4:30P

STANDARD OVERNIGHT

TRK# 7776 8326 5120
0201

EB HFDA

06790
CT-US
BDL

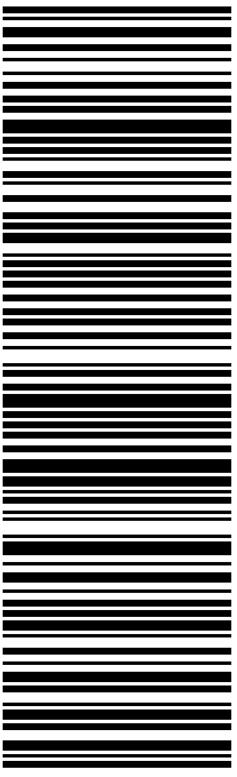

/templates/components/dotcom_label_contents/FoldInstr/en/Folding_instructions.html loading...
/templates/components/dotcom_label_contents/WarningsOriginalLabel/en/Folding_warning.html loading...
/templates/components/dotcom_label_contents/TnCDom/us/en/TC_dom.html loading...



August 18, 2022

Dear Customer,

The following is the proof-of-delivery for tracking number: 777683265120

Delivery Information:

Status:	Delivered	Delivered To:	Shipping/Receiving
Signed for by:	D.DUANE	Delivery Location:	
Service type:	FedEx Standard Overnight		
Special Handling:	Deliver Weekday		TORRINGTON, CT,
		Delivery date:	Aug 18, 2022 15:57

Shipping Information:

Tracking number:	777683265120	Ship Date:	Aug 17, 2022
		Weight:	0.5 LB/0.23 KG
Recipient:		Shipper:	
TORRINGTON, CT, US,		MERCHANTVILLE, NJ, US,	

Signature image is available. In order to view image and detailed information, the shipper or payor account number of the shipment must be provided.